

**LENSKART HQ**  
 GROUND FLOOR, VIPUL TECH SQUARE, GOLF COURSE RD, SECTOR 42, GURUGRAM, HARYANA  
 122002  
[WWW.LENSKART.COM](http://WWW.LENSKART.COM)

- GENERAL NOTES :-**
- DO NOT SCALE FROM THE DRAWINGS.
  - DIMENSIONS TO BE READ AND NOT MEASURED.
  - ALL DIMENSIONS ARE IN MM, UNLESS NOTED OTHERWISE.
  - ALL DRAWINGS SHOULD BE READ IN CONJUNCTION WITH OTHER RELEVANT ELECTRICAL, REFLECTED CEILING PLAN AND ALL RELEVANT SECTIONS.
  - ANY DISCREPANCIES ARE TO BE BROUGHT TO THE ATTENTION OF THE ARCHITECT AND RESOLVED BEFORE COMMENCEMENT OF ANY WORK.
  - THIS DRAWING IS THE COPYRIGHT OF LENSKART.COM & MUST NOT BE REPLICATED.

**DISCLAIMER :-**

"THIS DRAWING OR IDEA OR CONCEPT OR ARTWORK, INCLUDING THE ATTACHMENTS OR SAMPLES OR SUPPORTINGS THEREOF (SAID THE "CONCEPT"), IS SOLELY DEVELOPED BY LENSKART.COM, IS INTENDED FOR THE PURPOSE OF BUSINESS DEVELOPMENT, TO ONE OR MORE SPECIFIC INDIVIDUALS AND/OR ENTITIES AND HEREBY CLASSIFIED AS THE "INTELLECTUAL PROPERTY" OF LENSKART.COM, WHICH IS PRIVILEGED AND CANNOT BE USED, AS WHOLE OR IN PARTS OR IN ANY ALTERED FORM, WITHOUT A WRITTEN PERMISSION FROM THE MANAGEMENT OF LENSKART.COM. ANY SUCH UNAUTHORIZED USAGE SHALL BE CONSIDERED AS ILLEGITIMATE AND UNLAWFUL."

SITE DETAILS	
STORE AREA (SQ.FT.)	1159 SQ.FT
EXISTING SLAB MAXIMUM BOTTOM HEIGHT FROM F.F.L	390mm
EXISTING BEAM MINIMUM BOTTOM HEIGHT FROM F.F.L	360mm
BOTTOM OF CABLE TRAY HEIGHT FROM F.F.L.	290MM
FALSE CEILING BOTTOM HT.	NO FALSE CEILING
WALL FIXTURE HEIGHT	2400MM
BULKHEAD BOTTOM	2800 MM

**NOTE:**

**S T A T U S**

**GOOD FOR CONSTRUCTION**

R.No.	DATE	REVISION DESCRIPTION	DR.	CK.	AP.

**PROJECT TITLE:**  
2025- Lenskart Store

**SITE LOCATION:**  
BILASIPARA-COCO

**DRAWING TITLE:**  
COVER PAGE

<b>DRAWING NO:</b> ASM-BPR-CC- 00	<b>REVISION:</b> R0
<b>DATE:</b> 22.11.2025	<b>SCALE:</b> 1:60
<b>DRAWN BY:</b> Ar. Praveen Singh	<b>CHECKED BY:</b> 
	<b>APPROVED BY:</b> 

# 2025 - LENSKART STORE

## SITE - BILASIPARA-COCO

### DESIGN DOCKET

**PROJECT TITLE** 2025 - LENSKART STORE, BILASIPARA-COCO

**DATE** 19-11-2025

**CONTACT** Ar. Praveen Singh : +91 7527955298 (praveen.singh2@lenskart.com)







**GENERAL NOTES :-**

- DO NOT SCALE FROM THE DRAWINGS.
- DIMENSIONS TO BE READ AND NOT MEASURED.
- ALL DIMENSIONS ARE IN MM, UNLESS NOTED OTHERWISE.
- ALL DRAWINGS SHOULD BE READ IN CONJUNCTION WITH OTHER RELEVANT ELECTRICAL, REFLECTED CEILING PLAN AND ALL RELEVANT SECTIONS.
- ANY DISCREPANCIES ARE TO BE BROUGHT TO THE ATTENTION OF THE ARCHITECT AND RESOLVED BEFORE COMMENCEMENT OF ANY WORK.
- THIS DRAWING IS THE COPYRIGHT OF LENSKART.COM & MUST NOT BE REPLICATED.

**DISCLAIMER :-**

"THIS DRAWING OR IDEA OR CONCEPT OR ARTWORK, INCLUDING THE ATTACHMENTS OR SAMPLES OR SUPPORTING THEREOF (SAID THE "CONCEPT"), IS SOLELY DEVELOPED BY LENSKART.COM, IS INTENDED FOR THE PURPOSE OF BUSINESS DEVELOPMENT, TO ONE OR MORE SPECIFIC INDIVIDUALS AND/OR ENTITIES AND HEREBY CLASSIFIED AS THE "INTELLECTUAL PROPERTY" OF LENSKART.COM, WHICH IS PRIVILEGED AND CANNOT BE USED, AS WHOLE OR IN PARTS OR IN ANY ALTERED FORM, WITHOUT A WRITTEN PERMISSION FROM THE MANAGEMENT OF LENSKART.COM. ANY SUCH UNAUTHORIZED USAGE SHALL BE CONSIDERED AS ILLEGITIMATE AND UNLAWFUL."

**SITE DETAILS**

STORE AREA (SQ.FT.)	1159 SQ.FT
EXISTING SLAB MAXIMUM BOTTOM HEIGHT FROM F.F.L	3900mm
EXISTING BEAM MINIMUM BOTTOM HEIGHT FROM F.F.L	3600mm
BOTTOM OF CABLE TRAY HEIGHT FROM F.F.L.	2900MM
FALSE CEILING BOTTOM HT.	NO FALSE CEILING
WALL FIXTURE HEIGHT	2400MM
BULKHEAD BOTTOM	2800 MM

**NOTE:**

**STATUS**

**GOOD FOR CONSTRUCTION**

R.No.	DATE	REVISION DESCRIPTION	DR.	CK.	AP.

**PROJECT TITLE:**  
2025- Lenskart Store

**SITE LOCATION:**  
BILASIPARA-COCO

**DRAWING TITLE:**  
PARTITION & FINISHING LAYOUT

**DRAWING NO:**  
ASM-BPR-CC- 04

**REVISION:**  
R0


**DATE:**  
22.11.2025

**SCALE:**  
1:60

**DRAWN BY:**  
Ar. Praveen Singh

**CHECKED BY:**

**APPROVED BY:**

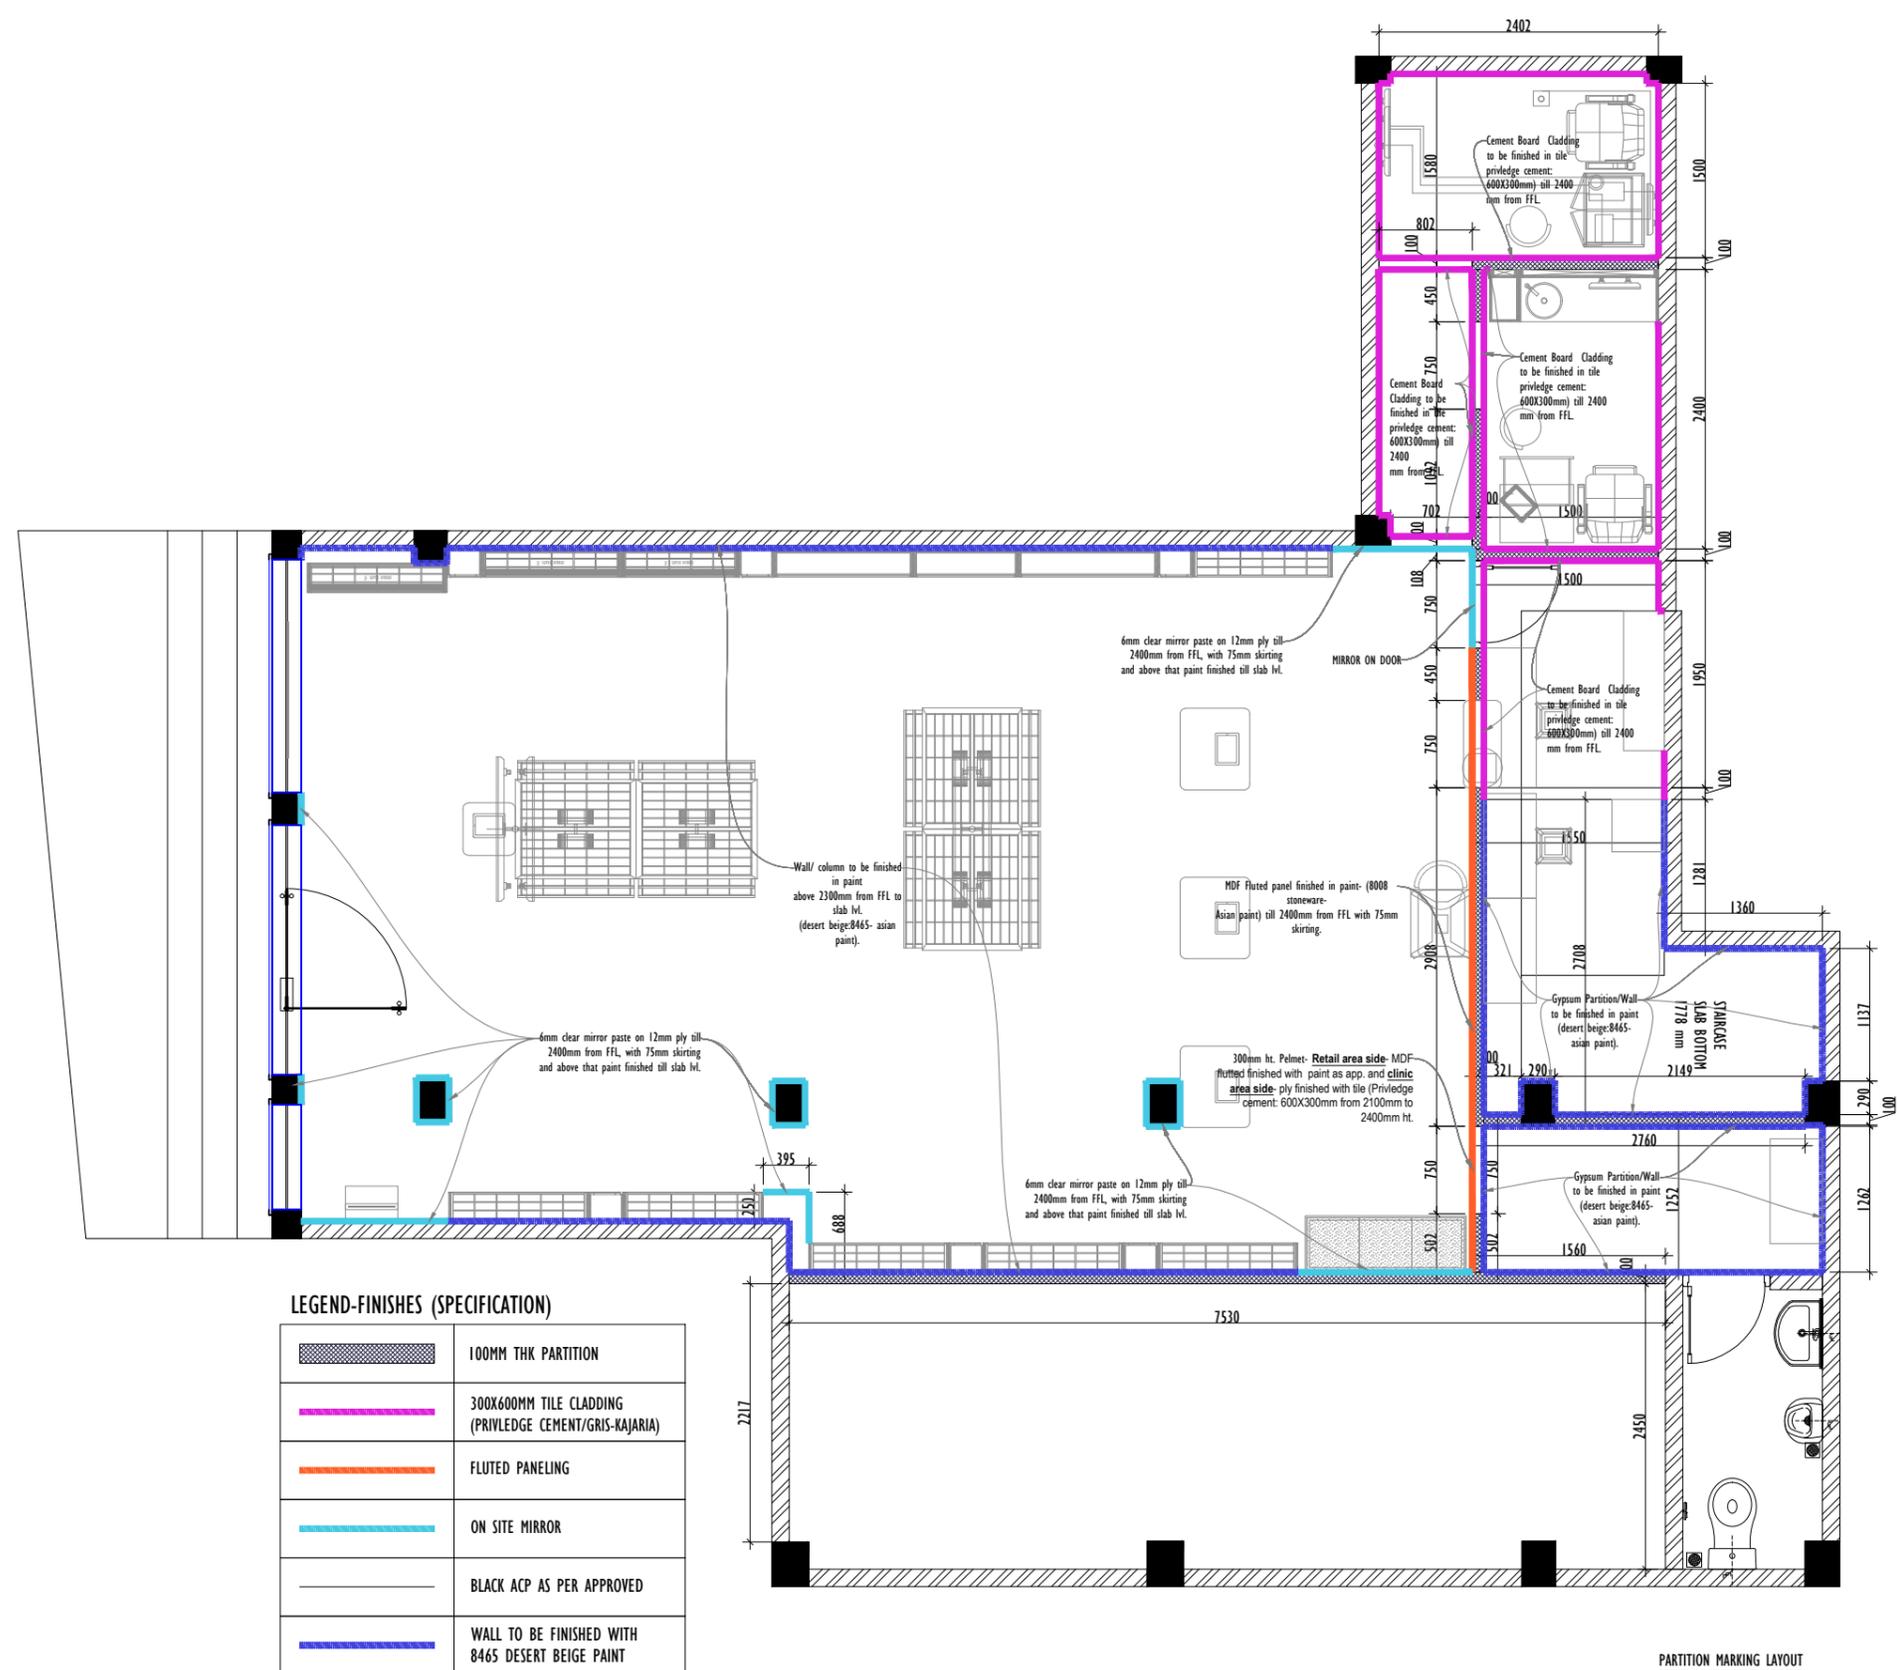

**LEGEND-FINISHES (SPECIFICATION)**

	100MM THK PARTITION
	300X600MM TILE CLADDING (PRIVLEDGE CEMENT/GRIS-KAJARIA)
	FLUTED PANELING
	ON SITE MIRROR
	BLACK ACP AS PER APPROVED
	WALL TO BE FINISHED WITH 8465 DESERT BEIGE PAINT
	BLACK LAMINATE AS/APPROVED

**NOTE:-**

- PARTITION HT. 2400MM FROM FFL

PARTITION MARKING LAYOUT

**GENERAL NOTES :-**

- DO NOT SCALE FROM THE DRAWINGS.
- DIMENSIONS TO BE READ AND NOT MEASURED.
- ALL DIMENSIONS ARE IN MM, UNLESS NOTED OTHERWISE.
- ALL DRAWINGS SHOULD BE READ IN CONJUNCTION WITH OTHER RELEVANT ELECTRICAL, REFLECTED CEILING PLAN AND ALL RELEVANT SECTIONS.
- ANY DISCREPANCIES ARE TO BE BROUGHT TO THE ATTENTION OF THE ARCHITECT AND RESOLVED BEFORE COMMENCEMENT OF ANY WORK.
- THIS DRAWING IS THE COPYRIGHT OF LENSKART.COM & MUST NOT BE REPLICATED.

**DISCLAIMER :-**

"THIS DRAWING OR IDEA OR CONCEPT OR ARTWORK, INCLUDING THE ATTACHMENTS OR SAMPLES OR SUPPORTINGS THEREOF (SAID THE "CONCEPT"), IS SOLELY DEVELOPED BY LENSKART.COM, IS INTENDED FOR THE PURPOSE OF BUSINESS DEVELOPMENT, TO ONE OR MORE SPECIFIC INDIVIDUALS AND/OR ENTITIES AND HEREBY CLASSIFIED AS THE "INTELLECTUAL PROPERTY" OF LENSKART.COM, WHICH IS PRIVILEGED AND CANNOT BE USED, AS WHOLE OR IN PARTS OR IN ANY ALTERED FORM, WITHOUT A WRITTEN PERMISSION FROM THE MANAGEMENT OF LENSKART.COM. ANY SUCH UNAUTHORIZED USAGE SHALL BE CONSIDERED AS ILLEGITIMATE AND UNLAWFUL."

**SITE DETAILS**

STORE AREA (SQ.FT.)	1159 SQ.FT
EXISTING SLAB MAXIMUM BOTTOM HEIGHT FROM F.F.L	3900mm
EXISTING BEAM MINIMUM BOTTOM HEIGHT FROM F.F.L	3600mm
BOTTOM OF CABLE TRAY HEIGHT FROM F.F.L	2900MM
FALSE CEILING BOTTOM HT.	NO FALSE CEILING
WALL FIXTURE HEIGHT	2400MM
BULKHEAD BOTTOM	2800 MM

**NOTE:**

**STATUS**

**GOOD FOR CONSTRUCTION**

R.No.	DATE	REVISION DESCRIPTION	DR.	CK.	AP.

**PROJECT TITLE:**  
2025- Lenskart Store


**SITE LOCATION:**  
BILASIPARA-COCO

**DRAWING TITLE:**  
ELECTRICAL LAYOUT

**DRAWING NO:** ASM-BPR-CC- 05 **REVISION:** R0

**DATE:** 22.11.2025 **SCALE:** 1:60

**DRAWN BY:** Ar. Praveen Singh **CHECKED BY:** **APPROVED BY:**

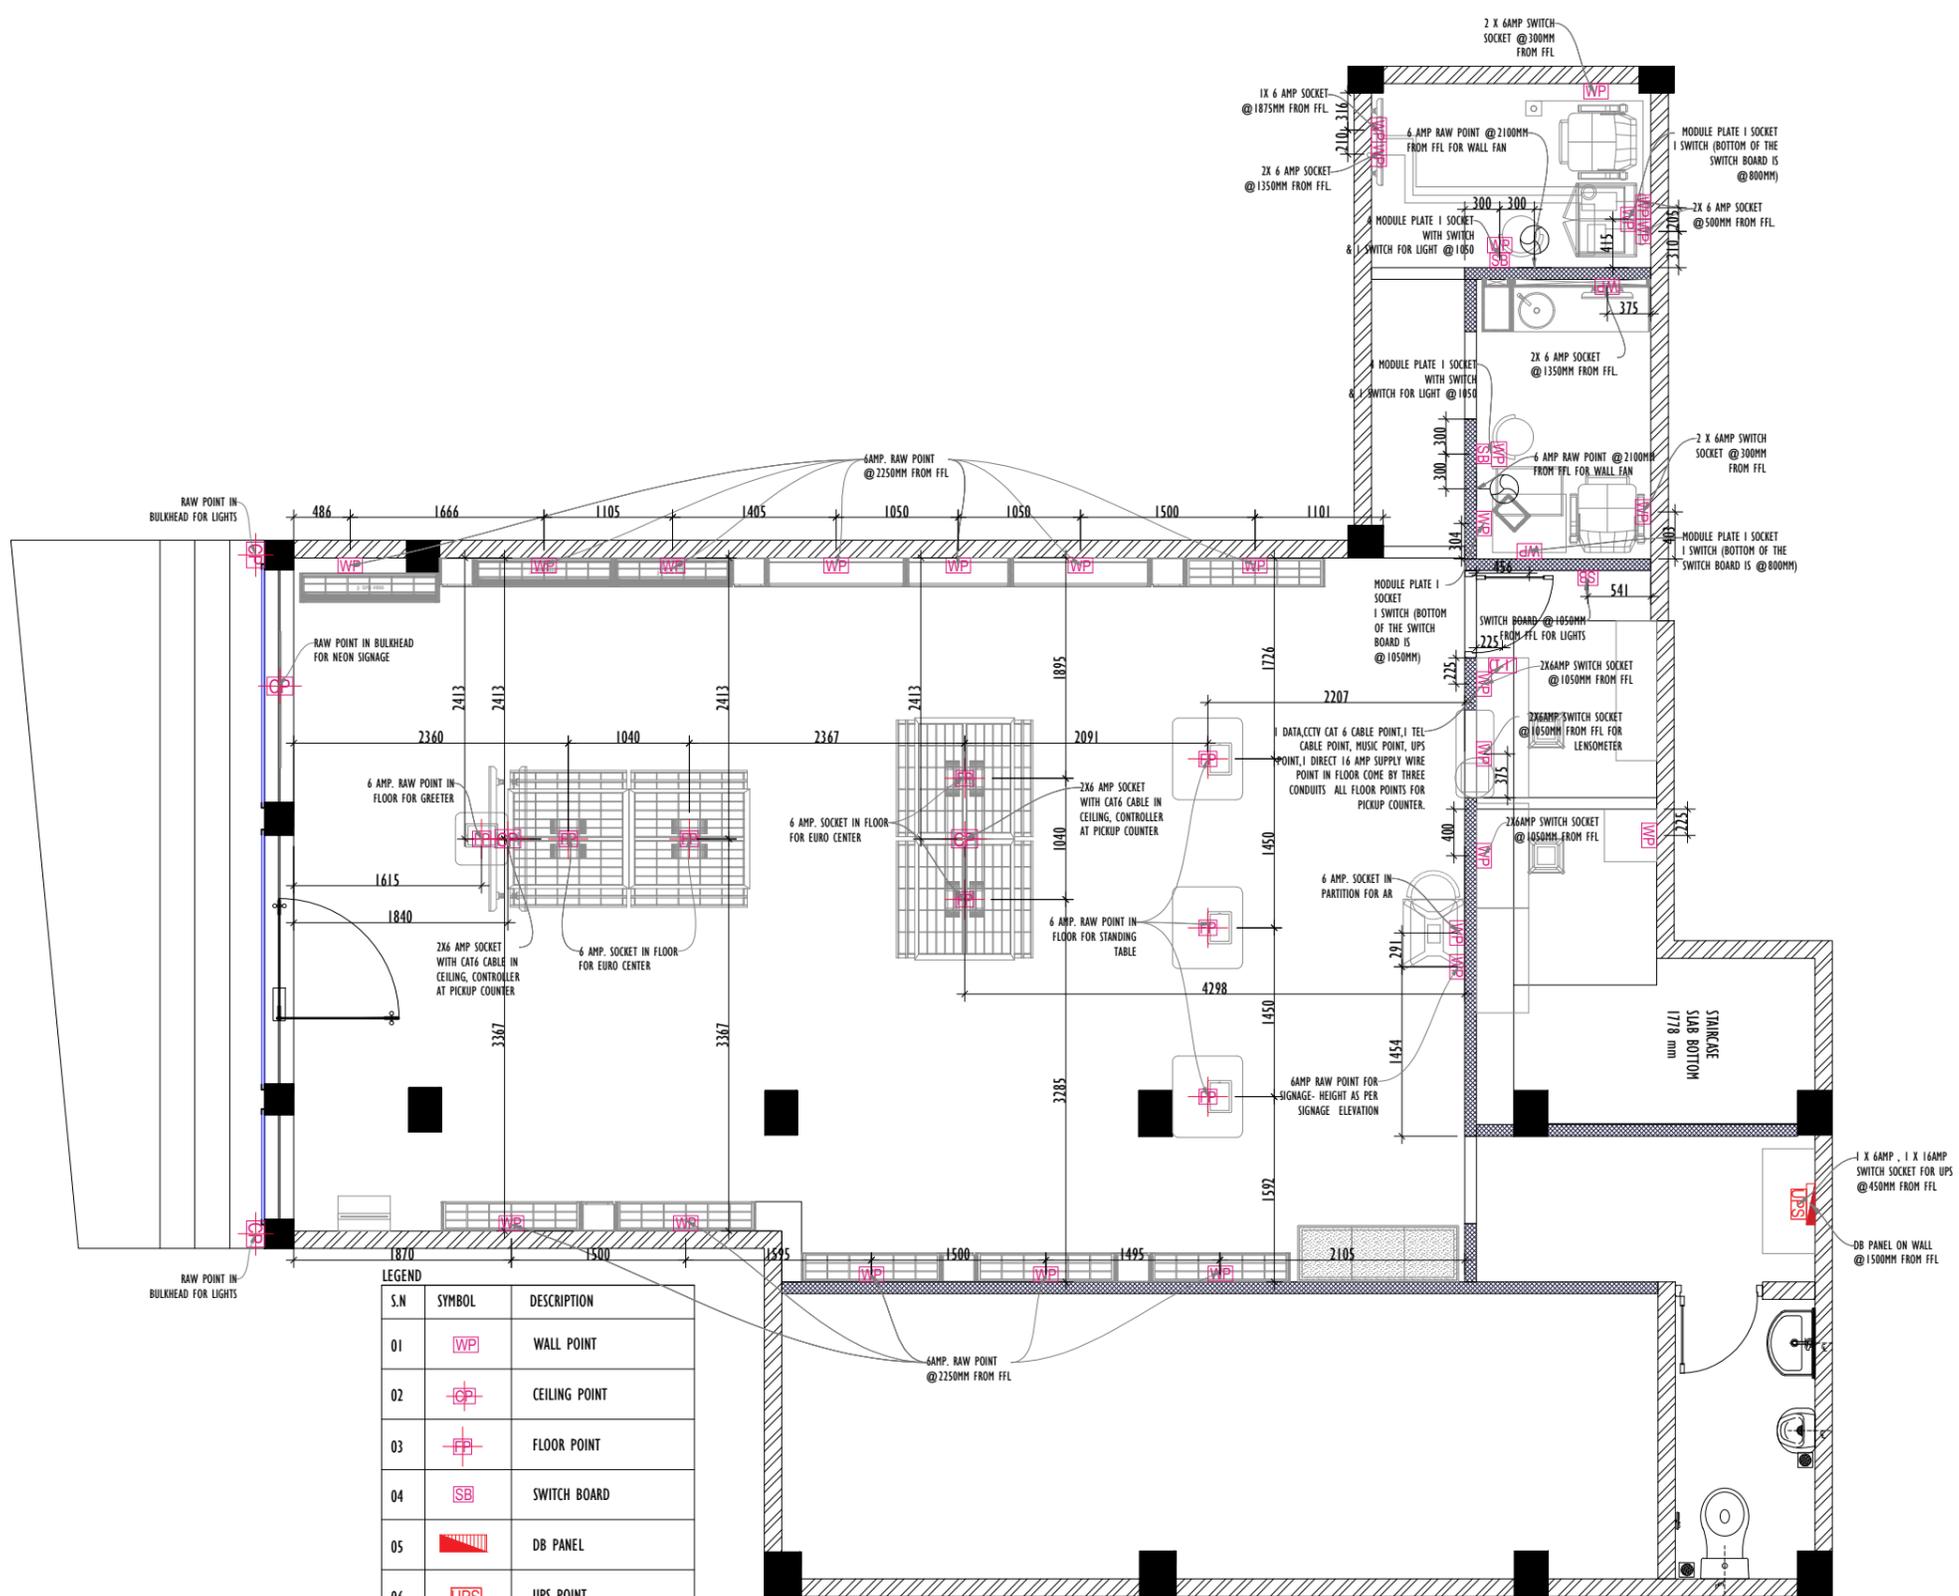

**LEGEND**

S.N	SYMBOL	DESCRIPTION
01	[W.P.]	WALL POINT
02	[C.P.]	CEILING POINT
03	[F.P.]	FLOOR POINT
04	[S.B.]	SWITCH BOARD
05	[DB]	DB PANEL
06	[UPS]	UPS POINT
07	[Data, CCTV, Cat 6, Music, Tel, Cable, UPS, etc.]	DATA, CCTV CAT 6 CABLE POINT, TEL CABLE POINT, MUSIC POINT, UPS POINT, DIRECT 16 AMP SUPPLY WIRE POINT IN FLOOR COME THROUGH THREE CONDUITS ALL FLOOR POINTS AT PICKUP COUNTER


**ELECTRICAL LAYOUT**

**GENERAL NOTES :-**

- DO NOT SCALE FROM THE DRAWINGS.
- DIMENSIONS TO BE READ AND NOT MEASURED.
- ALL DIMENSIONS ARE IN MM, UNLESS NOTED OTHERWISE.
- ALL DRAWINGS SHOULD BE READ IN CONJUNCTION WITH OTHER RELEVANT ELECTRICAL, REFLECTED CEILING PLAN AND ALL RELEVANT SECTIONS.
- ANY DISCREPANCIES ARE TO BE BROUGHT TO THE ATTENTION OF THE ARCHITECT AND RESOLVED BEFORE COMMENCEMENT OF ANY WORK.
- THIS DRAWING IS THE COPYRIGHT OF LENSKART.COM & MUST NOT BE REPLICATED.

**DISCLAIMER :-**

"THIS DRAWING OR IDEA OR CONCEPT OR ARTWORK, INCLUDING THE ATTACHMENTS OR SAMPLES OR SUPPORTINGS THEREOF (SAID THE "CONCEPT"), IS SOLELY DEVELOPED BY LENSKART.COM, IS INTENDED FOR THE PURPOSE OF BUSINESS DEVELOPMENT, TO ONE OR MORE SPECIFIC INDIVIDUALS AND/OR ENTITIES AND HEREBY CLASSIFIED AS THE "INTELLECTUAL PROPERTY" OF LENSKART.COM, WHICH IS PRIVILEGED AND CANNOT BE USED, AS WHOLE OR IN PARTS OR IN ANY ALTERED FORM, WITHOUT A WRITTEN PERMISSION FROM THE MANAGEMENT OF LENSKART.COM. ANY SUCH UNAUTHORIZED USAGE SHALL BE CONSIDERED AS ILLEGITIMATE AND UNLAWFUL."

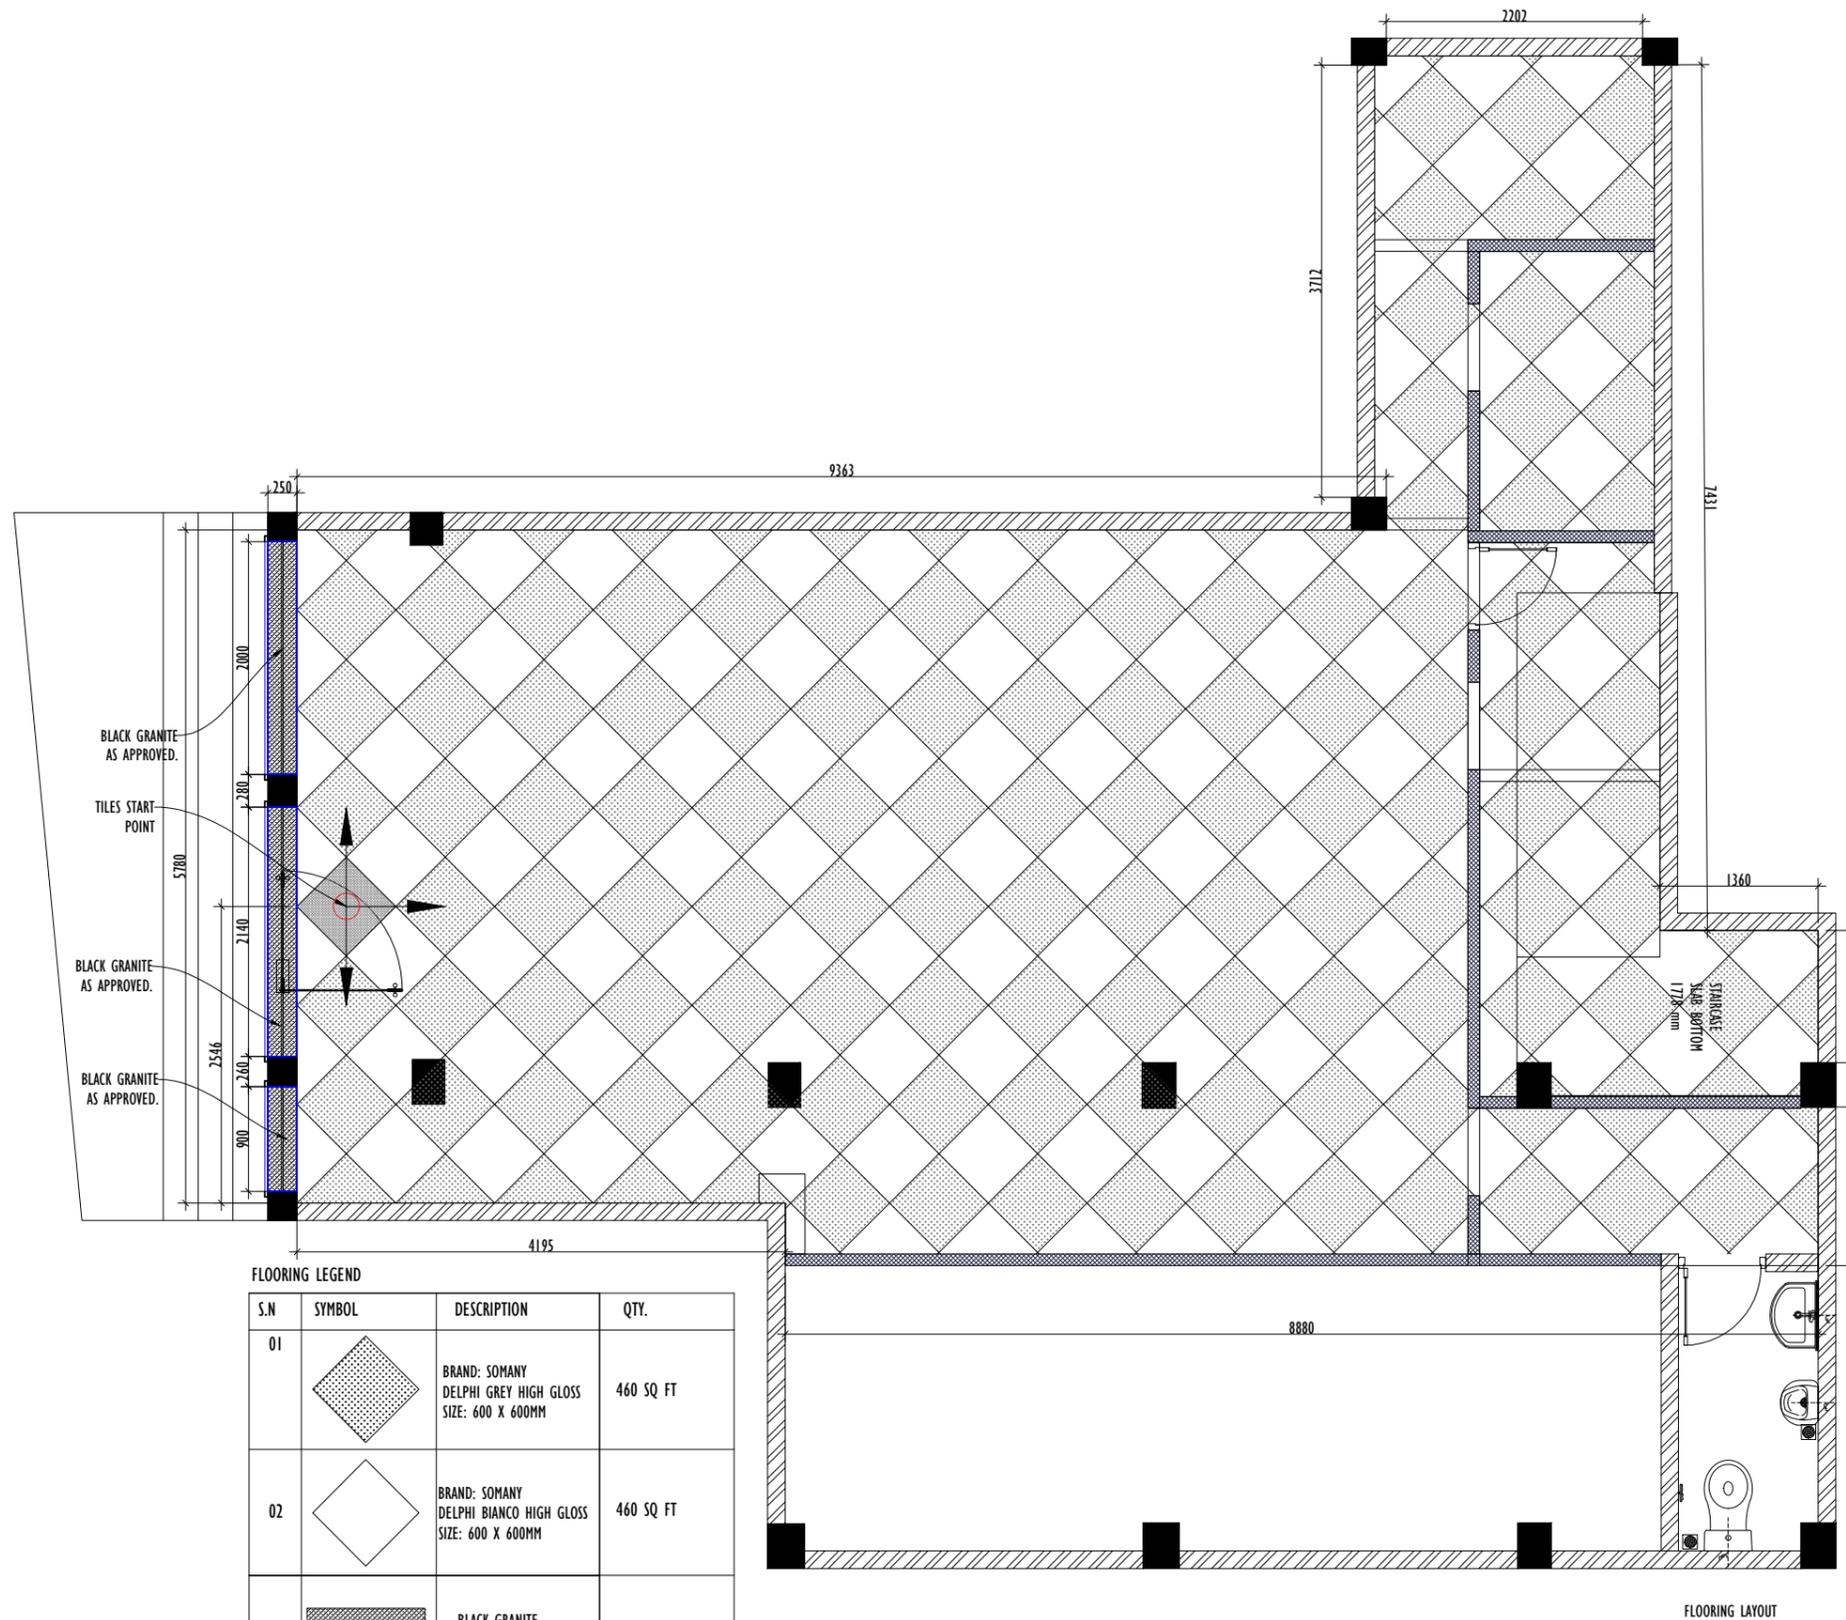

FLOORING LEGEND			
S.N	SYMBOL	DESCRIPTION	QTY.
01		BRAND: SOMANY DELPHI GREY HIGH GLOSS SIZE: 600 X 600MM	460 SQ FT
02		BRAND: SOMANY DELPHI BIANCO HIGH GLOSS SIZE: 600 X 600MM	460 SQ FT
03		BLACK GRANITE AS PER EXISTING	14 SQ FT

SITE DETAILS	
STORE AREA (SQ.FT.)	1159 SQ.FT
EXISTING SLAB MAXIMUM BOTTOM HEIGHT FROM F.F.L.	390mm
EXISTING BEAM MINIMUM BOTTOM HEIGHT FROM F.F.L.	360mm
BOTTOM OF CABLE TRAY HEIGHT FROM F.F.L.	290MM
FALSE CEILING BOTTOM HT.	NO FALSE CEILING
WALL FIXTURE HEIGHT	2400MM
BULKHEAD BOTTOM	2800 MM

**NOTE:**

**STATUS**

**GOOD FOR CONSTRUCTION**

R.No.	DATE	REVISION DESCRIPTION	DR.	CK.	AP.

**PROJECT TITLE:**  
2025- Lenskart Store

**SITE LOCATION:**  
BILASIPARA-COCO

**DRAWING TITLE:**  
FLOORING LAYOUT

**DRAWING NO:** ASM-BPR-CC- 06      **REVISION:** R0

**DATE:** 22.11.2025      **SCALE:** 1:60

**DRAWN BY:** Ar. Praveen Singh      **CHECKED BY:**      **APPROVED BY:**

**GENERAL NOTES :-**

- DO NOT SCALE FROM THE DRAWINGS.
- DIMENSIONS TO BE READ AND NOT MEASURED.
- ALL DIMENSIONS ARE IN MM, UNLESS NOTED OTHERWISE.
- ALL DRAWINGS SHOULD BE READ IN CONJUNCTION WITH OTHER RELEVANT ELECTRICAL, REFLECTED CEILING PLAN AND ALL RELEVANT SECTIONS.
- ANY DISCREPANCIES ARE TO BE BROUGHT TO THE ATTENTION OF THE ARCHITECT AND RESOLVED BEFORE COMMENCEMENT OF ANY WORK.
- THIS DRAWING IS THE COPYRIGHT OF LENSKART.COM & MUST NOT BE REPLICATED.

**DISCLAIMER :-**

"THIS DRAWING OR IDEA OR CONCEPT OR ARTWORK, INCLUDING THE ATTACHMENTS OR SAMPLES OR SUPPORTINGS THEREOF (SAID THE "CONCEPT"), IS SOLELY DEVELOPED BY LENSKART.COM, IS INTENDED FOR THE PURPOSE OF BUSINESS DEVELOPMENT, TO ONE OR MORE SPECIFIC INDIVIDUALS AND/OR ENTITIES AND HEREBY CLASSIFIED AS THE "INTELLECTUAL PROPERTY" OF LENSKART.COM, WHICH IS PRIVILEGED AND CANNOT BE USED, AS WHOLE OR IN PARTS OR IN ANY ALTERED FORM, WITHOUT A WRITTEN PERMISSION FROM THE MANAGEMENT OF LENSKART.COM. ANY SUCH UNAUTHORIZED USAGE SHALL BE CONSIDERED AS ILLEGITIMATE AND UNLAWFUL."

SITE DETAILS	
STORE AREA (SQ.FT.)	1159 SQ.FT
EXISTING SLAB MAXIMUM BOTTOM HEIGHT FROM F.F.L.	390mm
EXISTING BEAM MINIMUM BOTTOM HEIGHT FROM F.F.L.	360mm
BOTTOM OF CABLE TRAY HEIGHT FROM F.F.L.	2900MM
FALSE CEILING BOTTOM HT.	NO FALSE CEILING
WALL FIXTURE HEIGHT	2400MM
BULKHEAD BOTTOM	2800 MM

**NOTE:**

**STATUS**

**GOOD FOR CONSTRUCTION**

R.No.	DATE	REVISION DESCRIPTION	DR.	CK.	AP.

**PROJECT TITLE:**  
2025- Lenskart Store


**SITE LOCATION:**  
BILASIPARA-COCO

**DRAWING TITLE:**  
CABLE TRAY LAYOUT

**DRAWING NO:** ASM-BPR-CC- 07      **REVISION:** R0

**DATE:** 22.11.2025      **SCALE:** 1:60

**DRAWN BY:** Ar. Praveen Singh      **CHECKED BY:**      **APPROVED BY:**

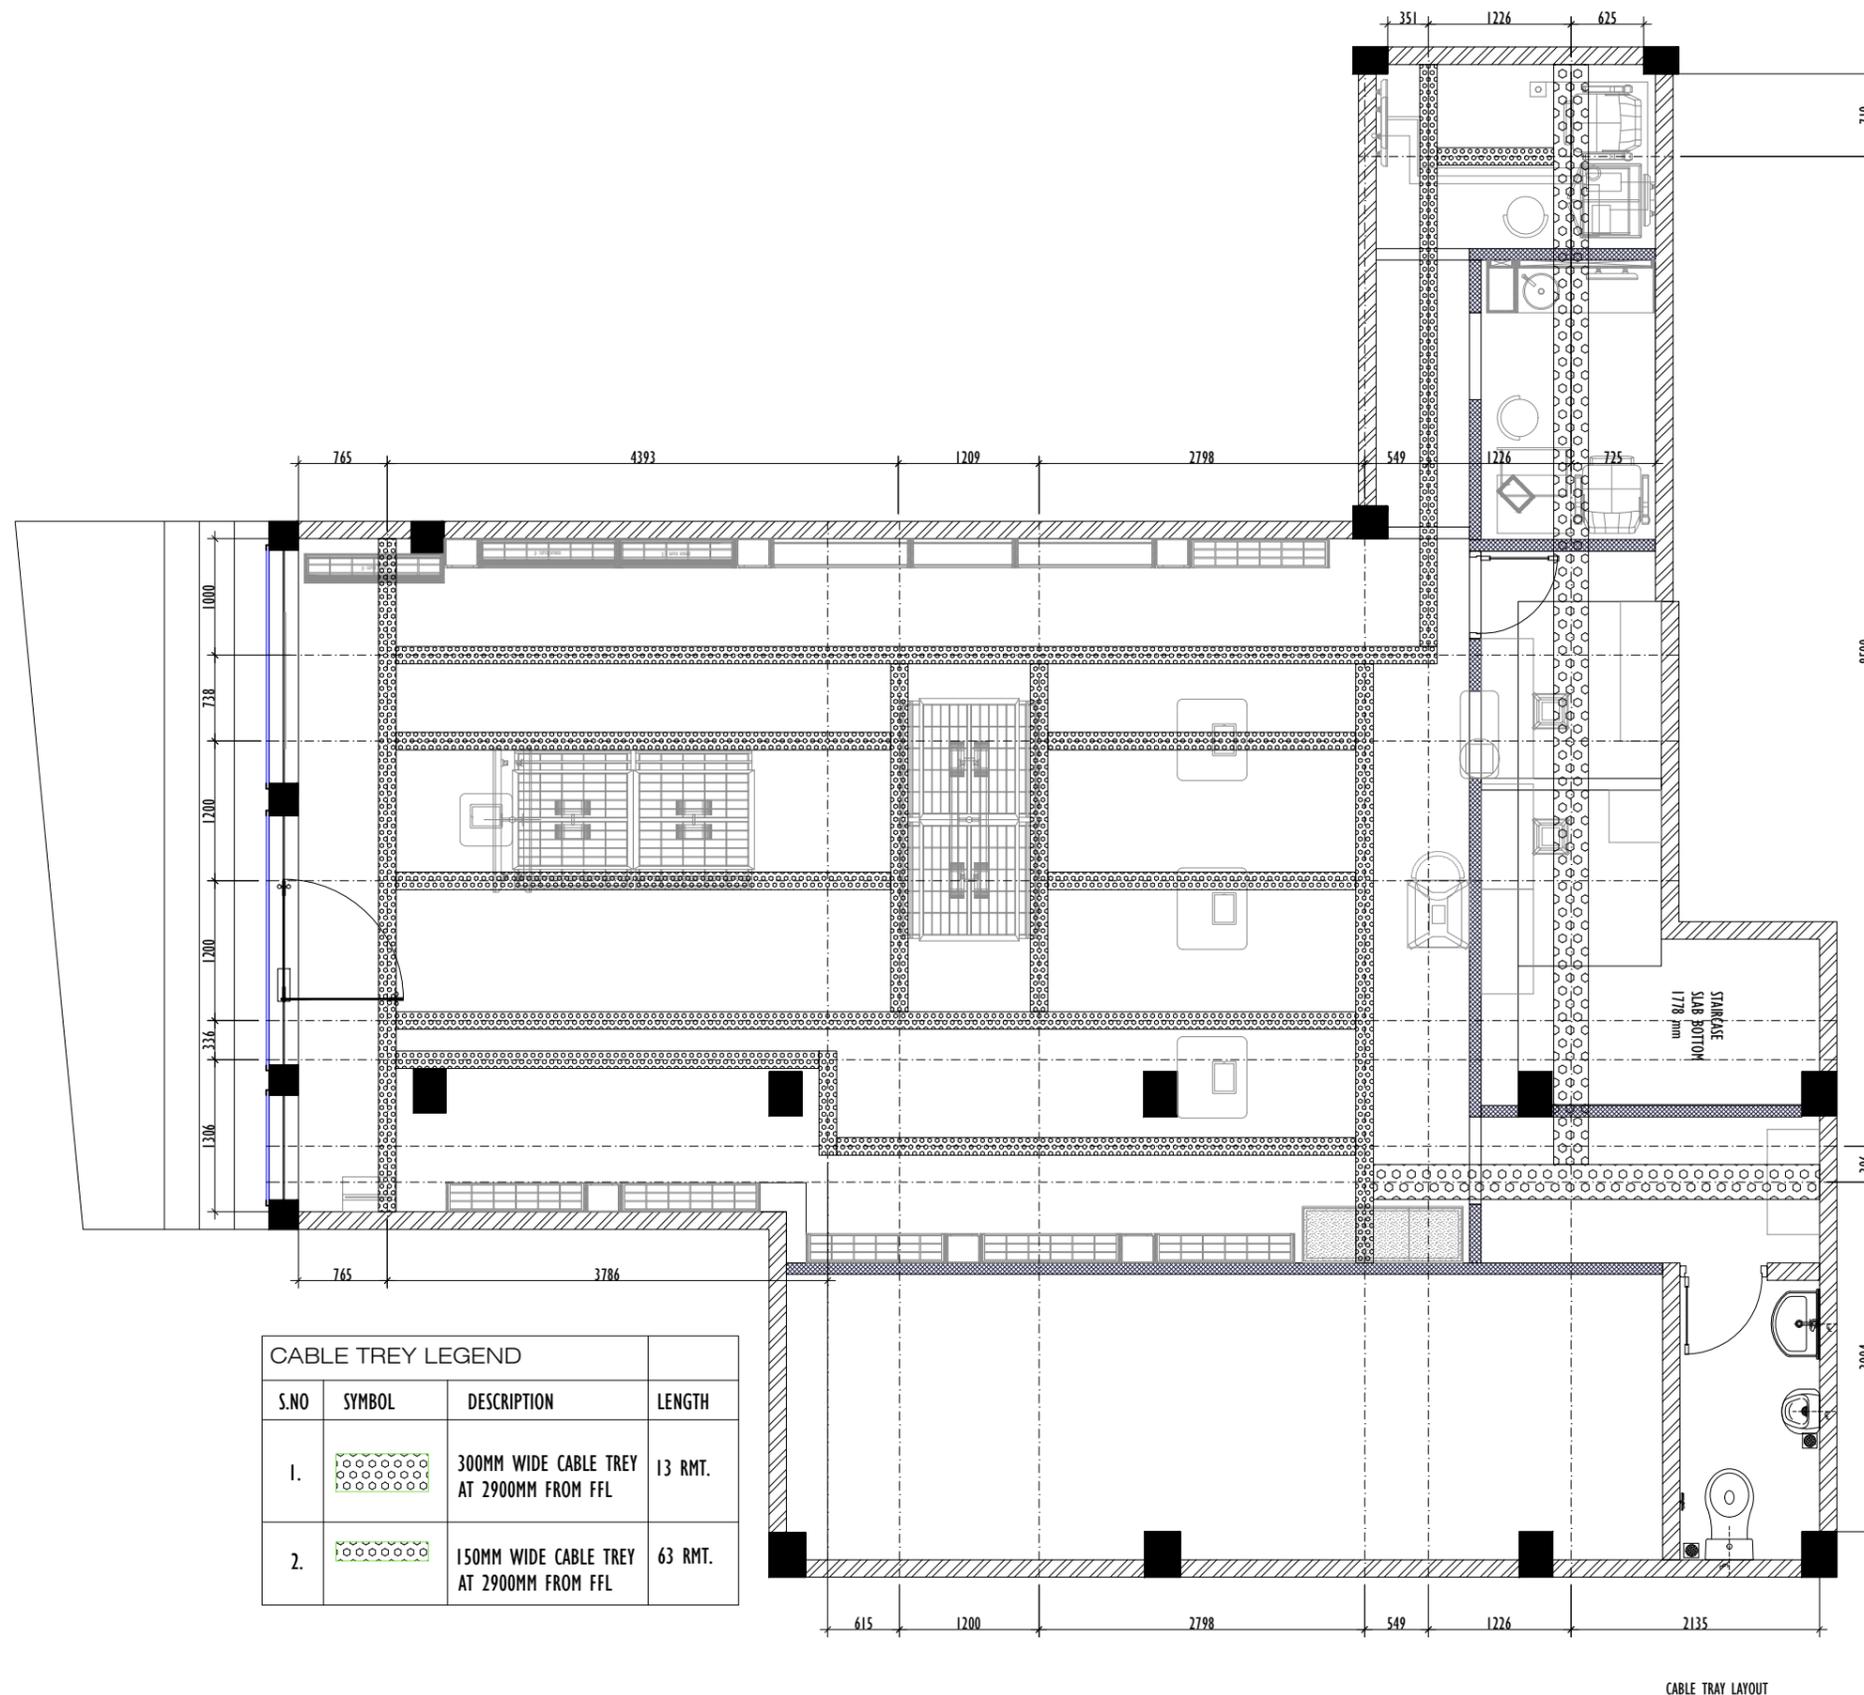

CABLE TRAY LEGEND			
S.NO	SYMBOL	DESCRIPTION	LENGTH
1.		300MM WIDE CABLE TRAY AT 2900MM FROM FFL	13 RMT.
2.		150MM WIDE CABLE TRAY AT 2900MM FROM FFL	63 RMT.

CABLE TRAY LAYOUT

**GENERAL NOTES :-**

- DO NOT SCALE FROM THE DRAWINGS.
- DIMENSIONS TO BE READ AND NOT MEASURED.
- ALL DIMENSIONS ARE IN MM, UNLESS NOTED OTHERWISE.
- ALL DRAWINGS SHOULD BE READ IN CONJUNCTION WITH OTHER RELEVANT ELECTRICAL, REFLECTED CEILING PLAN AND ALL RELEVANT SECTIONS.
- ANY DISCREPANCIES ARE TO BE BROUGHT TO THE ATTENTION OF THE ARCHITECT AND RESOLVED BEFORE COMMENCEMENT OF ANY WORK.
- THIS DRAWING IS THE COPYRIGHT OF LENSKART.COM & MUST NOT BE REPLICATED.

**DISCLAIMER :-**

"THIS DRAWING OR IDEA OR CONCEPT OR ARTWORK, INCLUDING THE ATTACHMENTS OR SAMPLES OR SUPPORTING THEREOF (SAID THE "CONCEPT"), IS SOLELY DEVELOPED BY LENSKART.COM, IS INTENDED FOR THE PURPOSE OF BUSINESS DEVELOPMENT, TO ONE OR MORE SPECIFIC INDIVIDUALS AND/OR ENTITIES AND HEREBY CLASSIFIED AS THE "INTELLECTUAL PROPERTY" OF LENSKART.COM, WHICH IS PRIVILEGED AND CANNOT BE USED, AS WHOLE OR IN PARTS OR IN ANY ALTERED FORM, WITHOUT A WRITTEN PERMISSION FROM THE MANAGEMENT OF LENSKART.COM. ANY SUCH UNAUTHORIZED USAGE SHALL BE CONSIDERED AS ILLEGITIMATE AND UNLAWFUL."

**SITE DETAILS**

STORE AREA (SQ.FT.)	1159 SQ.FT
EXISTING SLAB MAXIMUM BOTTOM HEIGHT FROM F.F.L.	390mm
EXISTING BEAM MINIMUM BOTTOM HEIGHT FROM F.F.L.	360mm
BOTTOM OF CABLE TRAY HEIGHT FROM F.F.L.	290MM
FALSE CEILING BOTTOM HT.	NO FALSE CEILING
WALL FIXTURE HEIGHT	2400MM
BULKHEAD BOTTOM	2800 MM

NOTE:

**STATUS**

**GOOD FOR CONSTRUCTION**

R.No.	DATE	REVISION DESCRIPTION	DR.	CK.	AP.

PROJECT TITLE:  
**2025- Lenskart Store**

SITE LOCATION:  
**BILASIPARA-COCO**

DRAWING TITLE:  
**LIGHTING LAYOUT**

DRAWING NO:  
**ASM-BPR-CC- 08**

REVISION:  
**RO**


DATE:  
 22.11.2025

SCALE:  
 1:60

DRAWN BY:  
 Ar. Praveen Singh

CHECKED BY:

APPROVED BY:

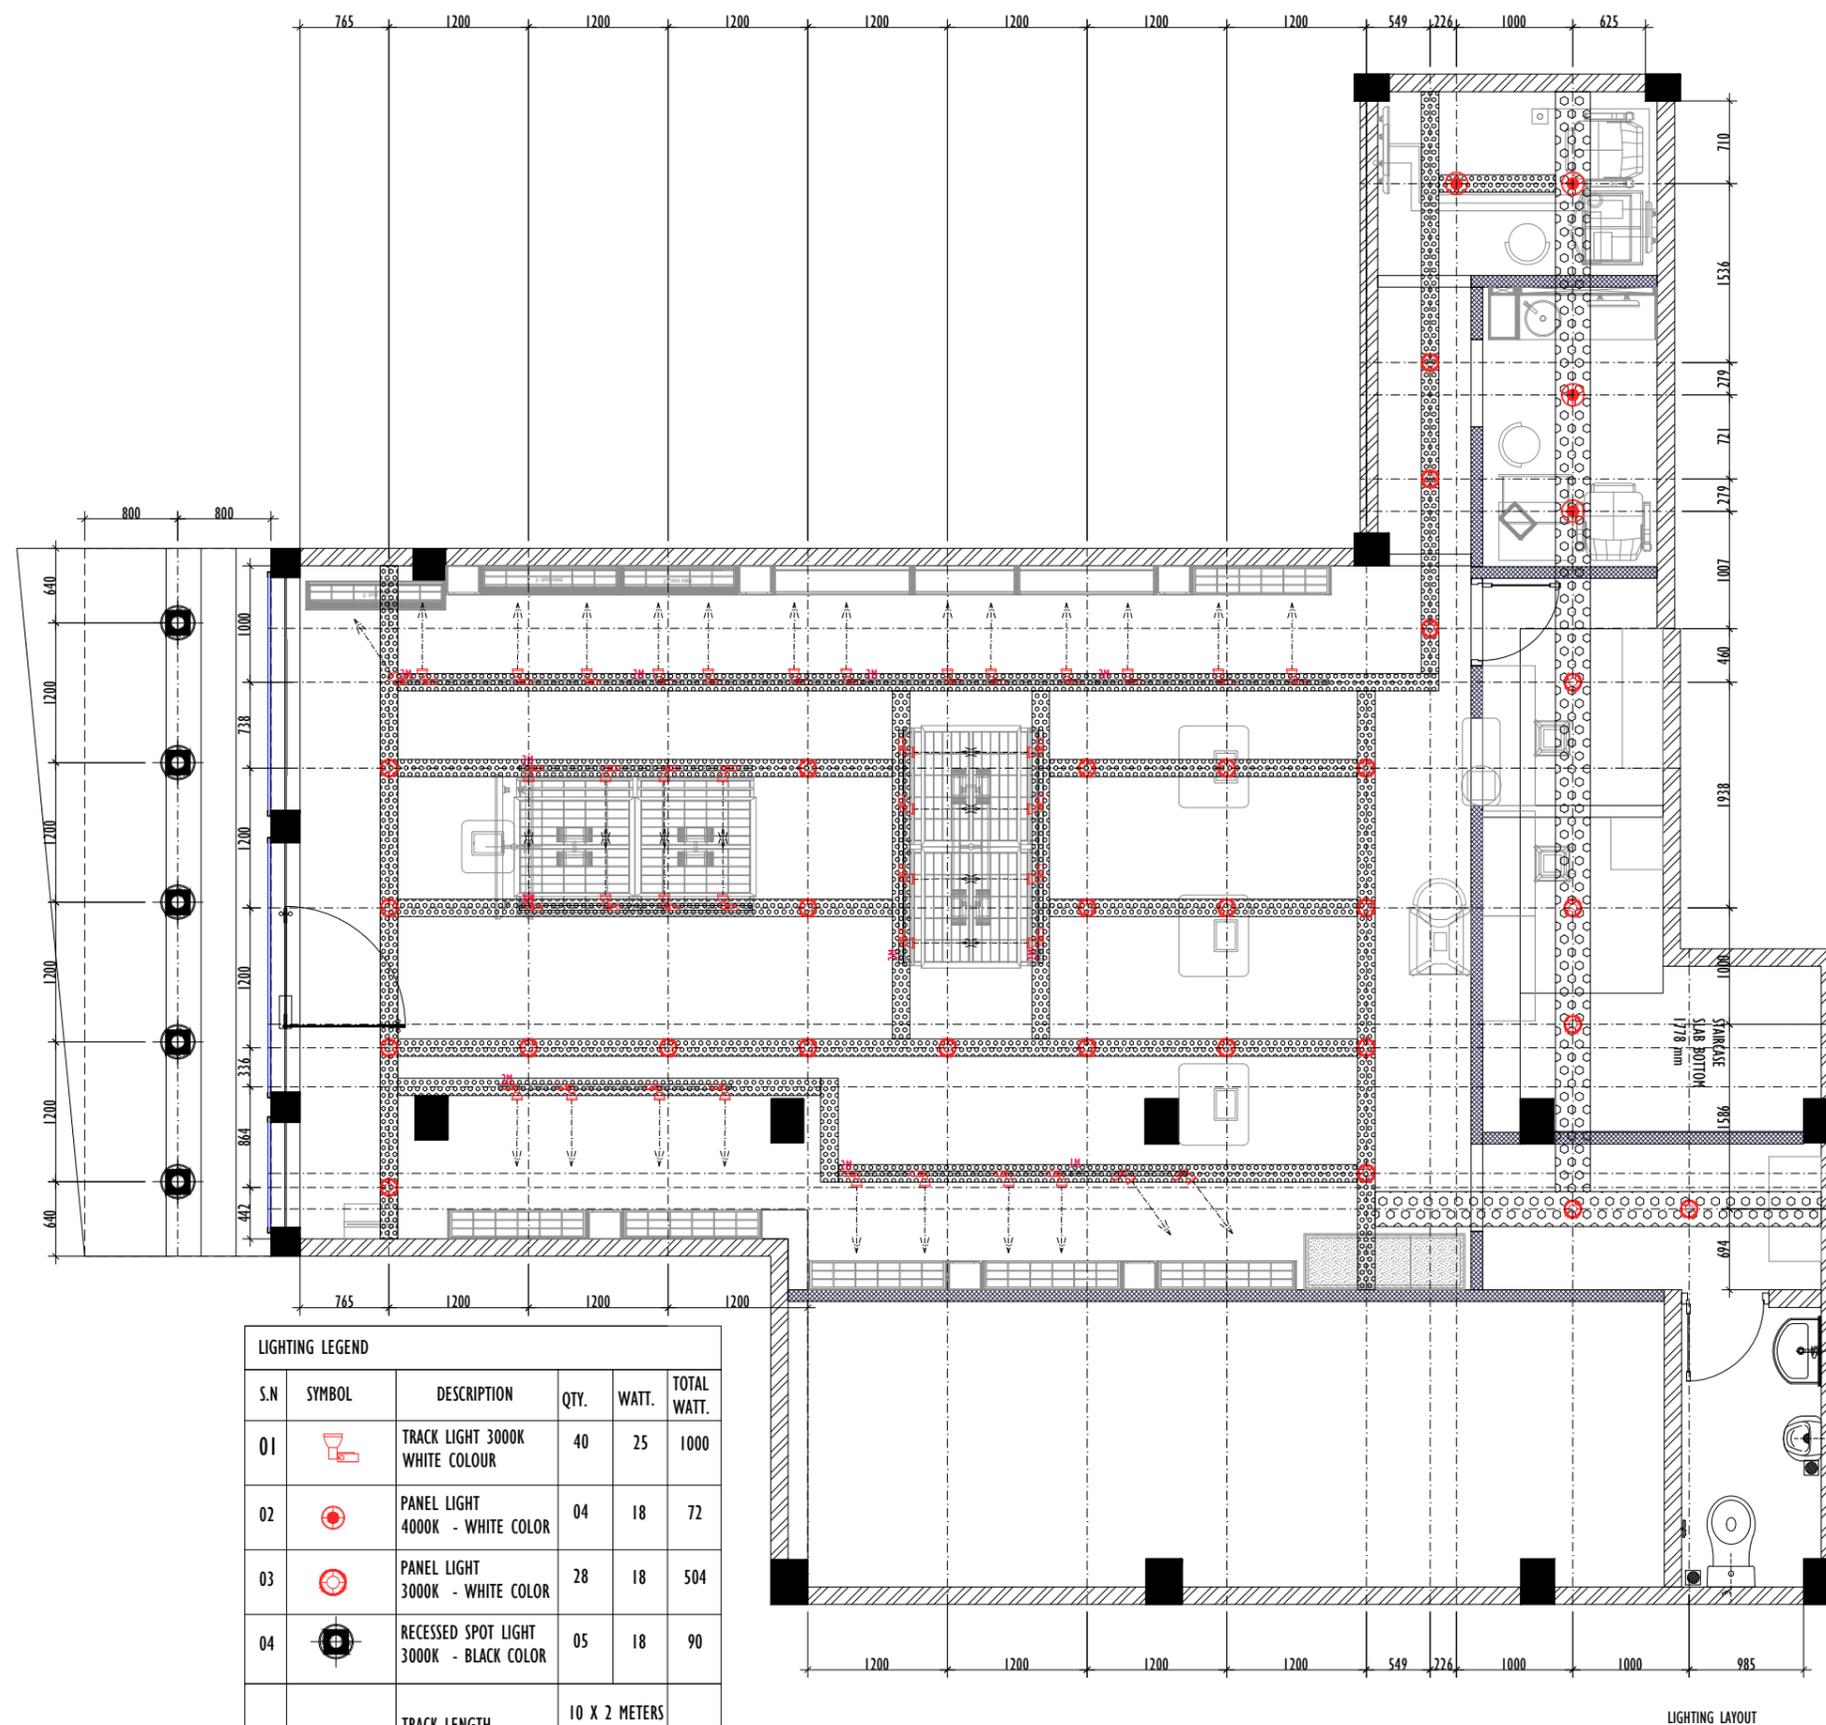

**LIGHTING LEGEND**

S.N	SYMBOL	DESCRIPTION	QTY.	WATT.	TOTAL WATT.
01		TRACK LIGHT 3000K WHITE COLOUR	40	25	1000
02		PANEL LIGHT 4000K - WHITE COLOR	04	18	72
03		PANEL LIGHT 3000K - WHITE COLOR	28	18	504
04		RECESSED SPOT LIGHT 3000K - BLACK COLOR	05	18	90
06		TRACK LENGTH - WHITE COLOR	10 X 2 METERS 01 X 1 METERS		

TOTAL -1666W

**GENERAL NOTES :-**

- DO NOT SCALE FROM THE DRAWINGS.
- DIMENSIONS TO BE READ AND NOT MEASURED.
- ALL DIMENSIONS ARE IN MM, UNLESS NOTED OTHERWISE.
- ALL DRAWINGS SHOULD BE READ IN CONJUNCTION WITH OTHER RELEVANT ELECTRICAL, REFLECTED CEILING PLAN AND ALL RELEVANT SECTIONS.
- ANY DISCREPANCIES ARE TO BE BROUGHT TO THE ATTENTION OF THE ARCHITECT AND RESOLVED BEFORE COMMENCEMENT OF ANY WORK.
- THIS DRAWING IS THE COPYRIGHT OF LENSKART.COM & MUST NOT BE REPLICATED.

**DISCLAIMER :-**

"THIS DRAWING OR IDEA OR CONCEPT OR ARTWORK, INCLUDING THE ATTACHMENTS OR SAMPLES OR SUPPORTINGS THEREOF (SAID THE "CONCEPT"), IS SOLELY DEVELOPED BY LENSKART.COM, IS INTENDED FOR THE PURPOSE OF BUSINESS DEVELOPMENT, TO ONE OR MORE SPECIFIC INDIVIDUALS AND/OR ENTITIES AND HEREBY CLASSIFIED AS THE "INTELLECTUAL PROPERTY" OF LENSKART.COM, WHICH IS PRIVILEGED AND CANNOT BE USED, AS WHOLE OR IN PARTS OR IN ANY ALTERED FORM, WITHOUT A WRITTEN PERMISSION FROM THE MANAGEMENT OF LENSKART.COM. ANY SUCH UNAUTHORIZED USAGE SHALL BE CONSIDERED AS ILLEGITIMATE AND UNLAWFUL."

SITE DETAILS	
STORE AREA (SQ.FT.)	1159 SQ.FT
EXISTING SLAB MAXIMUM BOTTOM HEIGHT FROM F.F.L.	390mm
EXISTING BEAM MINIMUM BOTTOM HEIGHT FROM F.F.L.	360mm
BOTTOM OF CABLE TRAY HEIGHT FROM F.F.L.	290MM
FALSE CEILING BOTTOM HT.	NO FALSE CEILING
WALL FIXTURE HEIGHT	2400MM
BULKHEAD BOTTOM	2800 MM

**NOTE:**

**STATUS**

**GOOD FOR CONSTRUCTION**

R.No.	DATE	REVISION DESCRIPTION	DR.	CK.	AP.

**PROJECT TITLE:**  
2025- Lenskart Store


**SITE LOCATION:**  
BILASIPARA-COCO

**DRAWING TITLE:**  
FIRE EXTINGUISHER PLAN

**DRAWING NO:** ASM-BPR-CC- 09      **REVISION:** R0

**DATE:** 22.11.2025      **SCALE:** 1:60

**DRAWN BY:** Ar. Praveen Singh      **CHECKED BY:**      **APPROVED BY:**

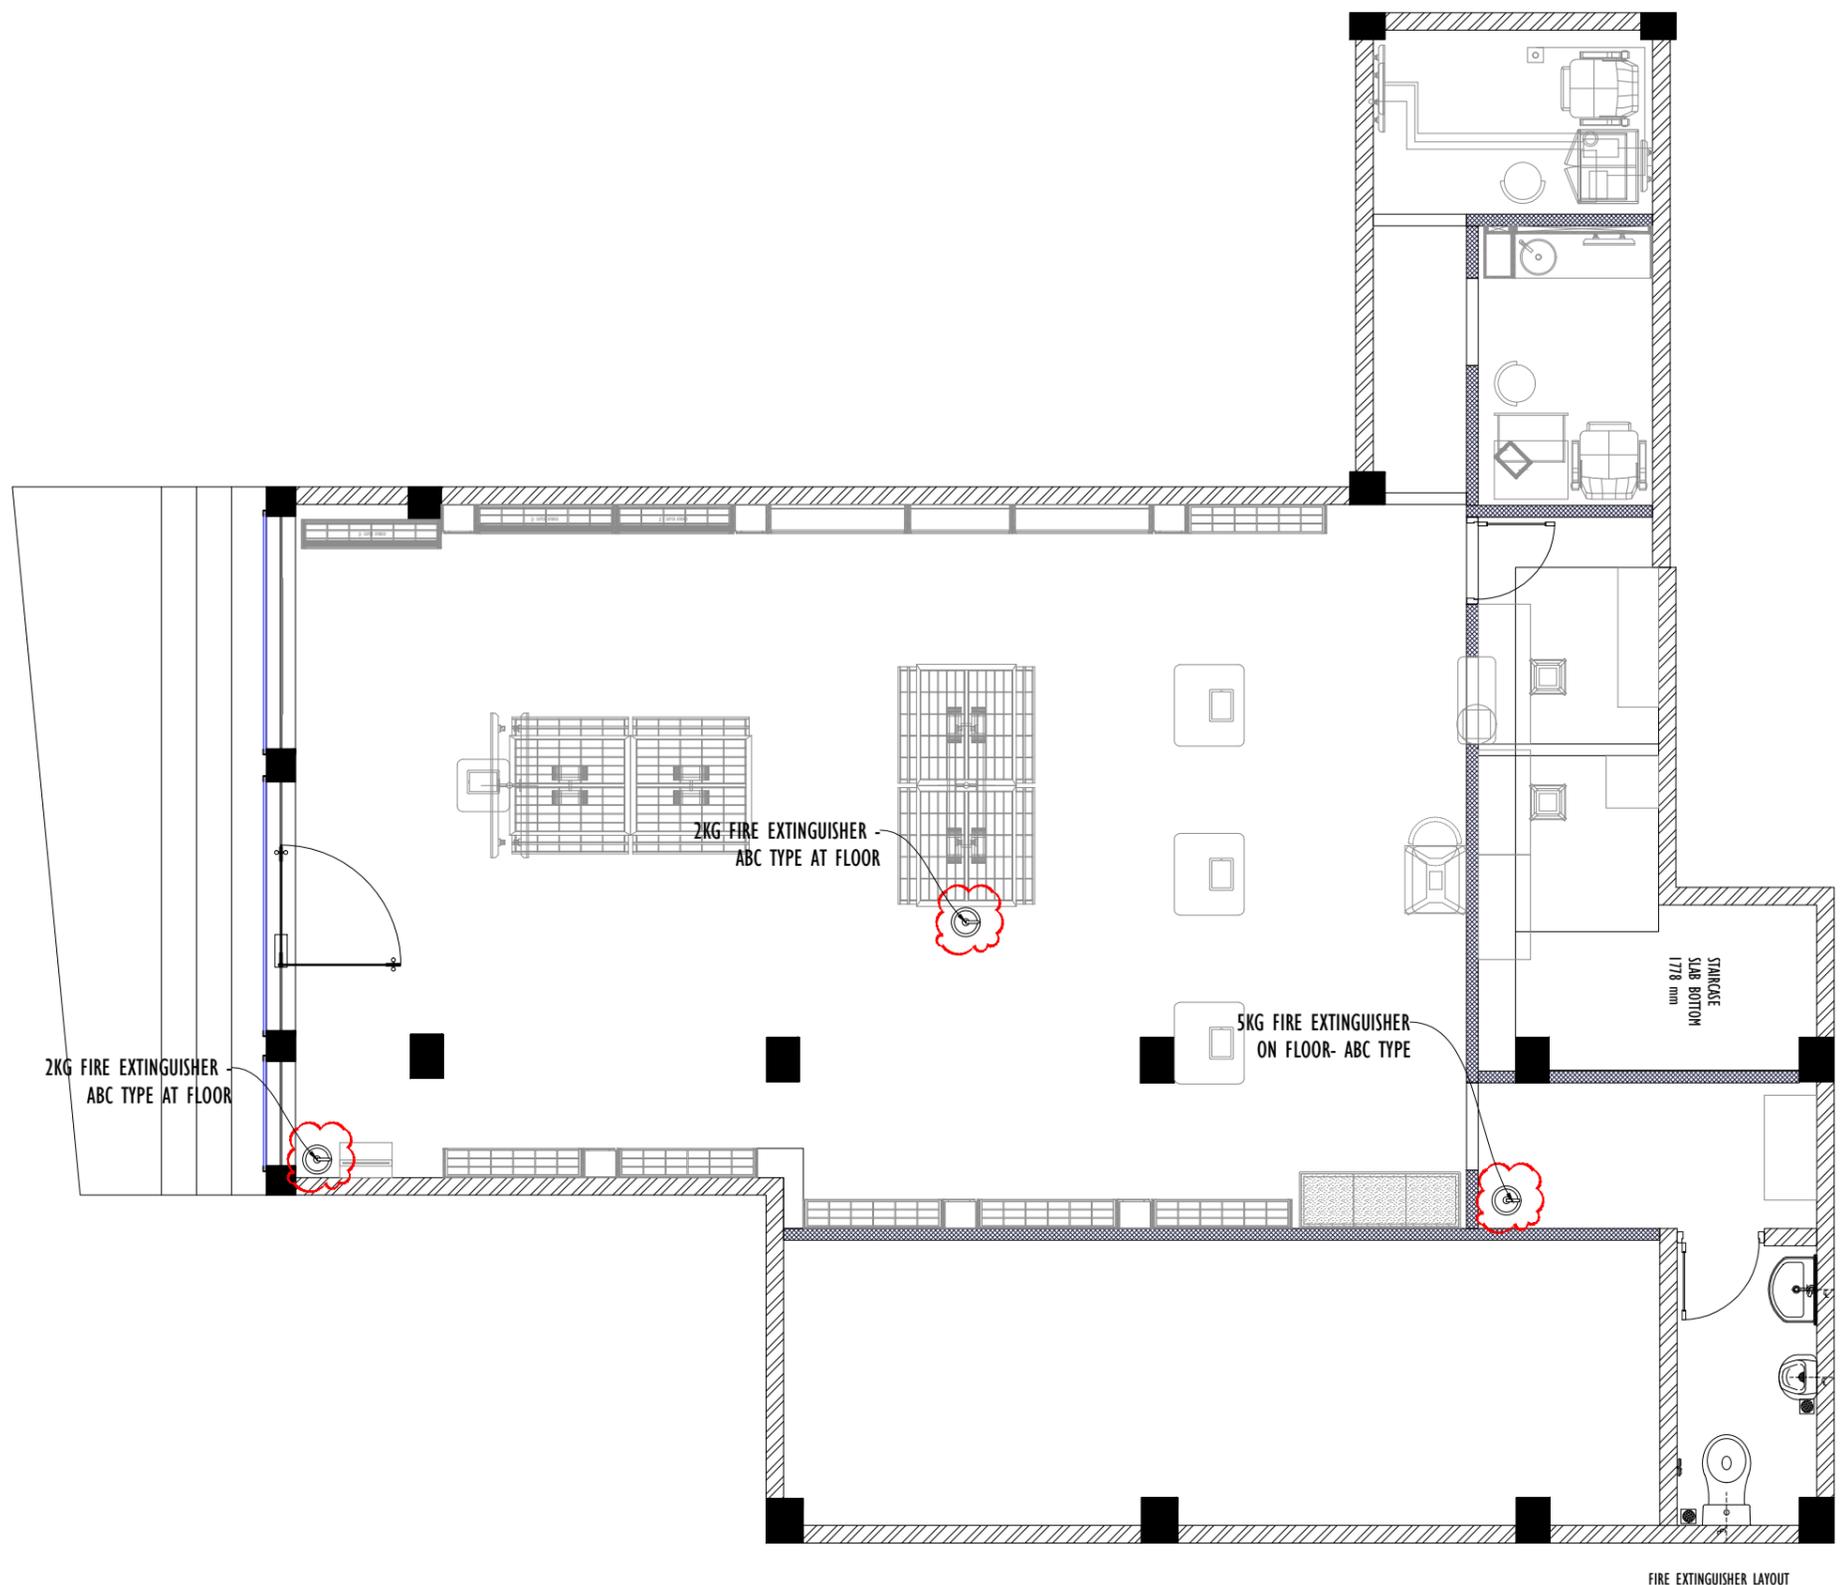

FIRE EXTINGUISHER LAYOUT

**GENERAL NOTES :-**

- DO NOT SCALE FROM THE DRAWINGS.
- DIMENSIONS TO BE READ AND NOT MEASURED.
- ALL DIMENSIONS ARE IN MM, UNLESS NOTED OTHERWISE.
- ALL DRAWINGS SHOULD BE READ IN CONJUNCTION WITH OTHER RELEVANT ELECTRICAL, REFLECTED CEILING PLAN AND ALL RELEVANT SECTIONS.
- ANY DISCREPANCIES ARE TO BE BROUGHT TO THE ATTENTION OF THE ARCHITECT AND RESOLVED BEFORE COMMENCEMENT OF ANY WORK.
- THIS DRAWING IS THE COPYRIGHT OF LENSKART.COM & MUST NOT BE REPLICATED.

**DISCLAIMER :-**

"THIS DRAWING OR IDEA OR CONCEPT OR ARTWORK, INCLUDING THE ATTACHMENTS OR SAMPLES OR SUPPORTINGS THEREOF (SAID THE "CONCEPT"), IS SOLELY DEVELOPED BY LENSKART.COM, IS INTENDED FOR THE PURPOSE OF BUSINESS DEVELOPMENT, TO ONE OR MORE SPECIFIC INDIVIDUALS AND/OR ENTITIES AND HEREBY CLASSIFIED AS THE "INTELLECTUAL PROPERTY" OF LENSKART.COM, WHICH IS PRIVILEGED AND CANNOT BE USED, AS WHOLE OR IN PARTS OR IN ANY ALTERED FORM, WITHOUT A WRITTEN PERMISSION FROM THE MANAGEMENT OF LENSKART.COM. ANY SUCH UNAUTHORIZED USAGE SHALL BE CONSIDERED AS ILLEGITIMATE AND UNLAWFUL."

SITE DETAILS	
STORE AREA (SQ.FT.)	1159 SQ.FT
EXISTING SLAB MAXIMUM BOTTOM HEIGHT FROM F.F.L.	390mm
EXISTING BEAM MINIMUM BOTTOM HEIGHT FROM F.F.L.	360mm
BOTTOM OF CABLE TRAY HEIGHT FROM F.F.L.	290MM
FALSE CEILING BOTTOM HT.	NO FALSE CEILING
WALL FIXTURE HEIGHT	2400MM
BULKHEAD BOTTOM	2800 MM


**NOTE:**

**STATUS**

**GOOD FOR CONSTRUCTION**

R.No.	DATE	REVISION DESCRIPTION	DR.	CK.	AP.

<b>PROJECT TITLE:</b> 2025- Lenskart Store	
<b>SITE LOCATION:</b> BILASIPARA-COCO	
<b>DRAWING TITLE:</b> CCTV LAYOUT	
<b>DRAWING NO:</b> ASM-BPR-CC- 10	<b>REVISION:</b> R0
<b>DATE:</b> 22.11.2025	<b>SCALE:</b> 1:60
<b>DRAWN BY:</b> Ar. Praveen Singh	<b>CHECKED BY:</b> 
<b>APPROVED BY:</b> 	

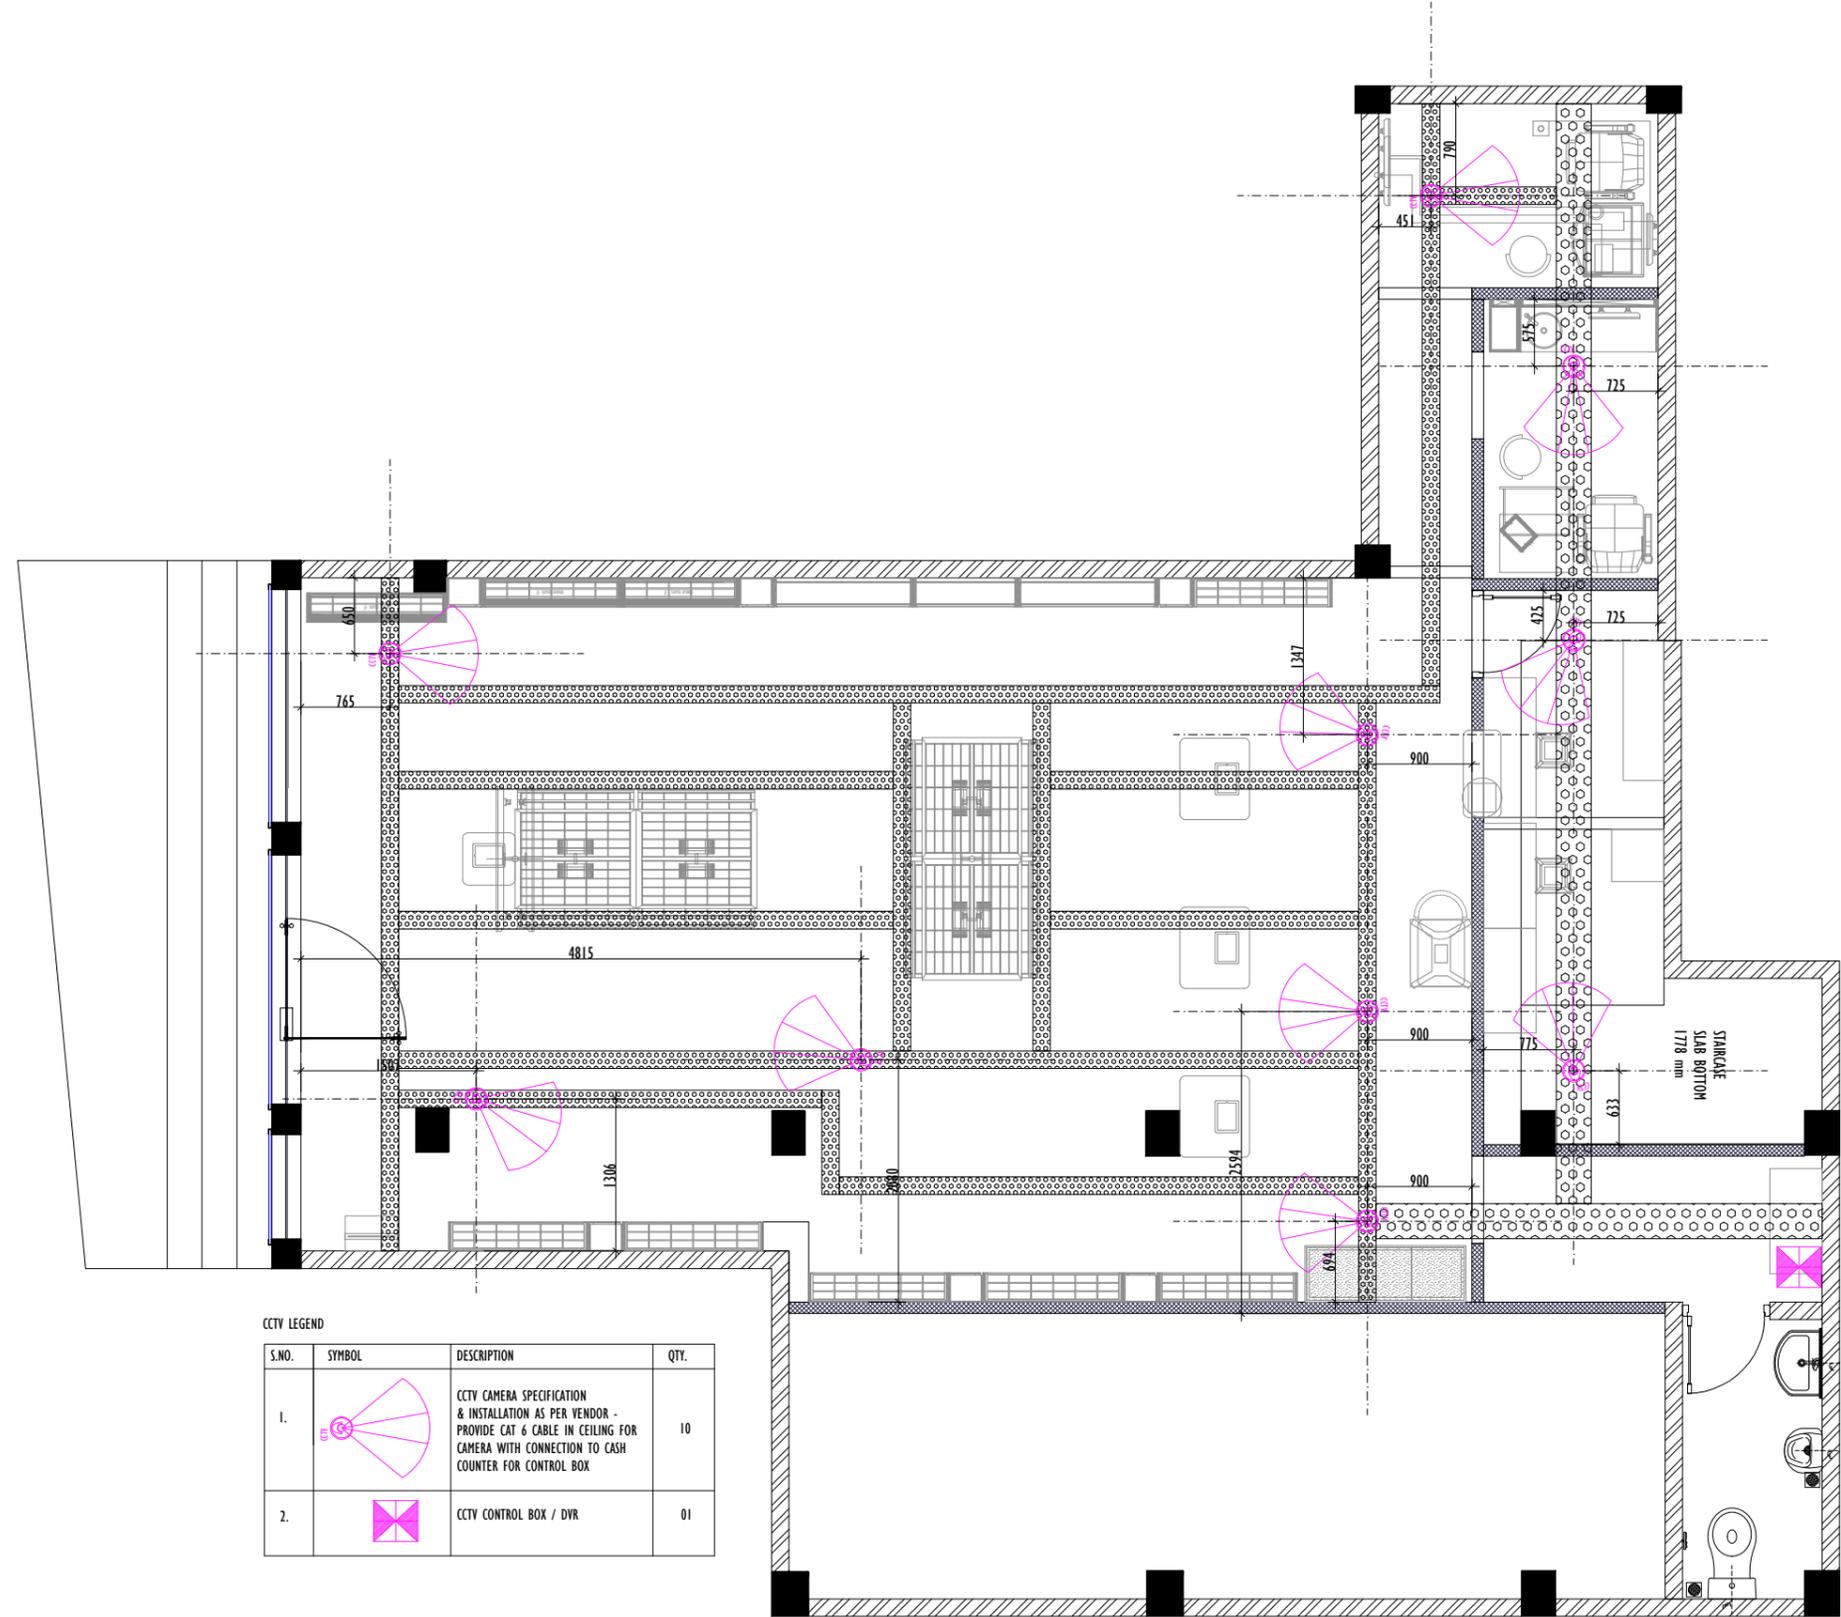

**CCTV LEGEND**

S.NO.	SYMBOL	DESCRIPTION	QTY.
1.		CCTV CAMERA SPECIFICATION & INSTALLATION AS PER VENDOR - PROVIDE CAT 6 CABLE IN CEILING FOR CAMERA WITH CONNECTION TO CASH COUNTER FOR CONTROL BOX	10
2.		CCTV CONTROL BOX / DVR	01

CCTV LAYOUT

- GENERAL NOTES :-**
- DO NOT SCALE FROM THE DRAWINGS.
  - DIMENSIONS TO BE READ AND NOT MEASURED.
  - ALL DIMENSIONS ARE IN MM, UNLESS NOTED OTHERWISE.
  - ALL DRAWINGS SHOULD BE READ IN CONJUNCTION WITH OTHER RELEVANT ELECTRICAL, REFLECTED CEILING PLAN AND ALL RELEVANT SECTIONS.
  - ANY DISCREPANCIES ARE TO BE BROUGHT TO THE ATTENTION OF THE ARCHITECT AND RESOLVED BEFORE COMMENCEMENT OF ANY WORK.
  - THIS DRAWING IS THE COPYRIGHT OF LENSKART.COM & MUST NOT BE REPLICATED.

**DISCLAIMER :-**

"THIS DRAWING OR IDEA OR CONCEPT OR ARTWORK, INCLUDING THE ATTACHMENTS OR SAMPLES OR SUPPORTINGS THEREOF (SAID THE "CONCEPT"), IS SOLELY DEVELOPED BY LENSKART.COM, IS INTENDED FOR THE PURPOSE OF BUSINESS DEVELOPMENT, TO ONE OR MORE SPECIFIC INDIVIDUALS AND/OR ENTITIES AND HEREBY CLASSIFIED AS THE "INTELLECTUAL PROPERTY" OF LENSKART.COM, WHICH IS PRIVILEGED AND CANNOT BE USED, AS WHOLE OR IN PARTS OR IN ANY ALTERED FORM, WITHOUT A WRITTEN PERMISSION FROM THE MANAGEMENT OF LENSKART.COM. ANY SUCH UNAUTHORIZED USAGE SHALL BE CONSIDERED AS ILLEGITIMATE AND UNLAWFUL."

**SITE DETAILS**

STORE AREA (SQ.FT.)	1159 SQ.FT
EXISTING SLAB MAXIMUM BOTTOM HEIGHT FROM F.F.L.	390mm
EXISTING BEAM MINIMUM BOTTOM HEIGHT FROM F.F.L.	360mm
BOTTOM OF CABLE TRAY HEIGHT FROM F.F.L.	290MM
FALSE CEILING BOTTOM HT.	NO FALSE CEILING
WALL FIXTURE HEIGHT	2400MM
BULKHEAD BOTTOM	2800 MM

**NOTE:**

**STATUS**

**GOOD FOR CONSTRUCTION**


R.No.	DATE	REVISION DESCRIPTION	DR.	CK.	AP.

**PROJECT TITLE:**  
2025- Lenskart Store

**SITE LOCATION:**  
BILASIPARA-COCO

**DRAWING TITLE:**  
SPEAKER LAYOUT

<b>DRAWING NO:</b> ASM-BPR-CC- 11	<b>REVISION:</b> R0
<b>DATE:</b> 22.11.2025	<b>SCALE:</b> 1:60
<b>DRAWN BY:</b> Ar. Praveen Singh	<b>CHECKED BY:</b> 
	<b>APPROVED BY:</b> 

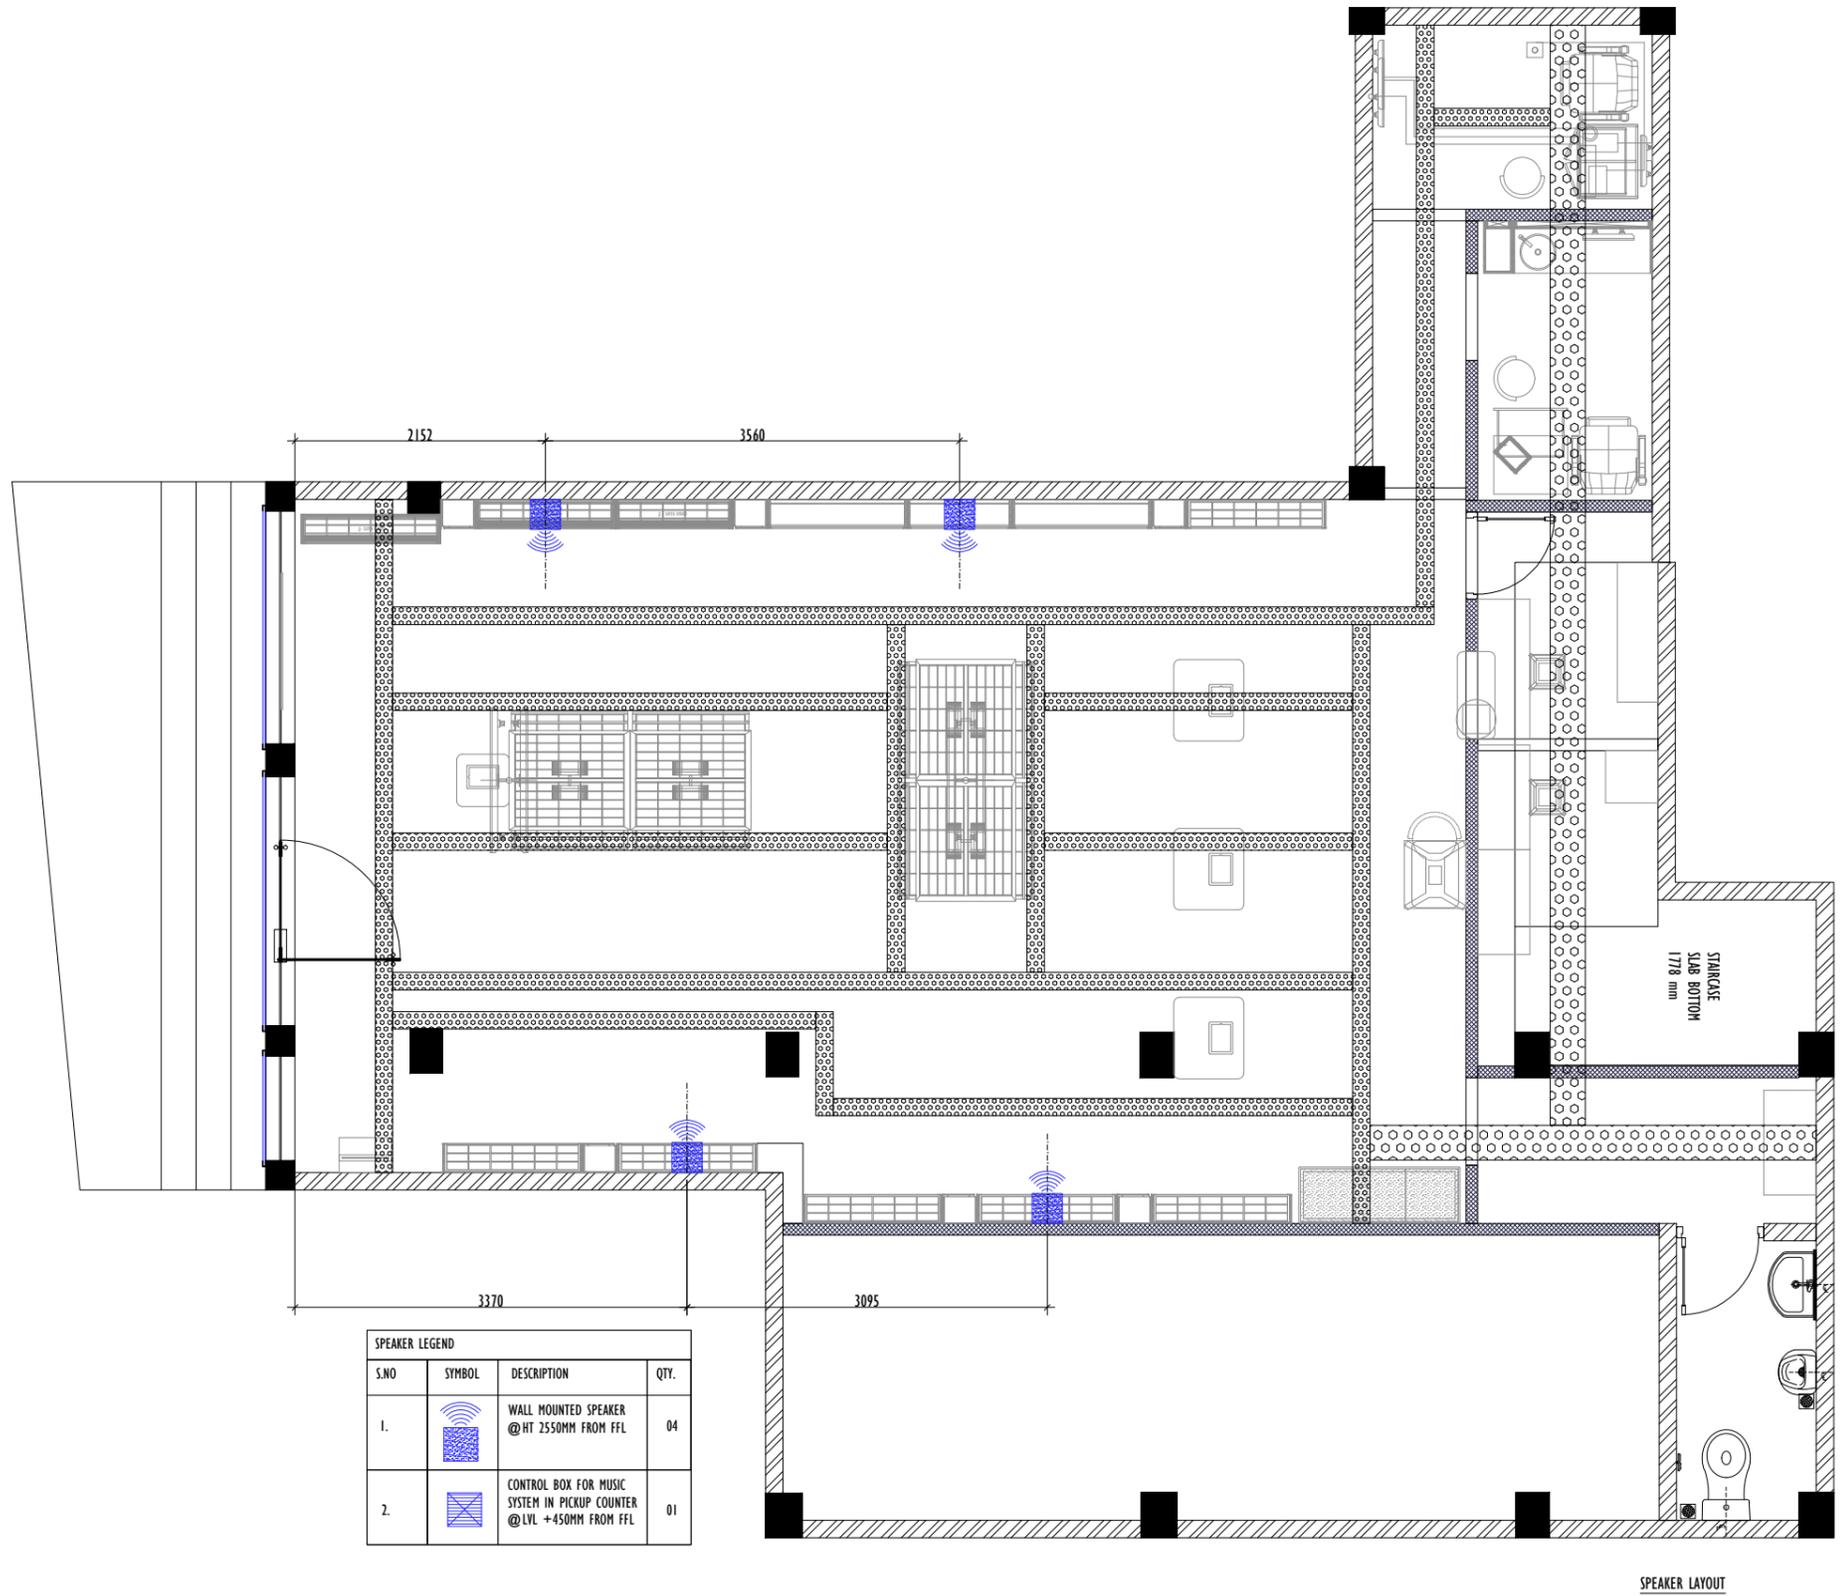

S.NO	SYMBOL	DESCRIPTION	QTY.
1.		WALL MOUNTED SPEAKER @ HT 2550MM FROM FFL	04
2.		CONTROL BOX FOR MUSIC SYSTEM IN PICKUP COUNTER @ LVL +450MM FROM FFL	01

- GENERAL NOTES :-**
- DO NOT SCALE FROM THE DRAWINGS.
  - DIMENSIONS TO BE READ AND NOT MEASURED.
  - ALL DIMENSIONS ARE IN MM, UNLESS NOTED OTHERWISE.
  - ALL DRAWINGS SHOULD BE READ IN CONJUNCTION WITH OTHER RELEVANT ELECTRICAL, REFLECTED CEILING PLAN AND ALL RELEVANT SECTIONS.
  - ANY DISCREPANCIES ARE TO BE BROUGHT TO THE ATTENTION OF THE ARCHITECT AND RESOLVED BEFORE COMMENCEMENT OF ANY WORK.
  - THIS DRAWING IS THE COPYRIGHT OF LENSKART.COM & MUST NOT BE REPLICATED.

**DISCLAIMER :-**

"THIS DRAWING OR IDEA OR CONCEPT OR ARTWORK, INCLUDING THE ATTACHMENTS OR SAMPLES OR SUPPORTINGS THEREOF (SAID THE "CONCEPT"), IS SOLELY DEVELOPED BY LENSKART.COM, IS INTENDED FOR THE PURPOSE OF BUSINESS DEVELOPMENT, TO ONE OR MORE SPECIFIC INDIVIDUALS AND/OR ENTITIES AND HEREBY CLASSIFIED AS THE "INTELLECTUAL PROPERTY" OF LENSKART.COM, WHICH IS PRIVILEGED AND CANNOT BE USED, AS WHOLE OR IN PARTS OR IN ANY ALTERED FORM, WITHOUT A WRITTEN PERMISSION FROM THE MANAGEMENT OF LENSKART.COM. ANY SUCH UNAUTHORIZED USAGE SHALL BE CONSIDERED AS ILLEGITIMATE AND UNLAWFUL."

**SITE DETAILS**

STORE AREA (SQ.FT.)	1159 SQ.FT
EXISTING SLAB MAXIMUM BOTTOM HEIGHT FROM F.F.L.	3900mm
EXISTING BEAM MINIMUM BOTTOM HEIGHT FROM F.F.L.	3600mm
BOTTOM OF CABLE TRAY HEIGHT FROM F.F.L.	2900MM
FALSE CEILING BOTTOM HT.	NO FALSE CEILING
WALL FIXTURE HEIGHT	2400MM
BULKHEAD BOTTOM	2800 MM


**NOTE:**

**STATUS**

**GOOD FOR CONSTRUCTION**

R.No.	DATE	REVISION DESCRIPTION	DR.	CK.	AP.

<b>PROJECT TITLE:</b> 2025- Lenskart Store		
<b>SITE LOCATION:</b> BILASIPARA-COCO		
<b>DRAWING TITLE:</b> AC LAYOUT		
<b>DRAWING NO:</b> ASM-BPR-CC- 12		<b>REVISION:</b> R0
<b>DATE:</b> 22.11.2025	<b>SCALE:</b> 1:60	<b>APPROVED BY:</b>
<b>DRAWN BY:</b> Ar. Praveen Singh	<b>CHECKED BY:</b>	<b>APPROVED BY:</b>

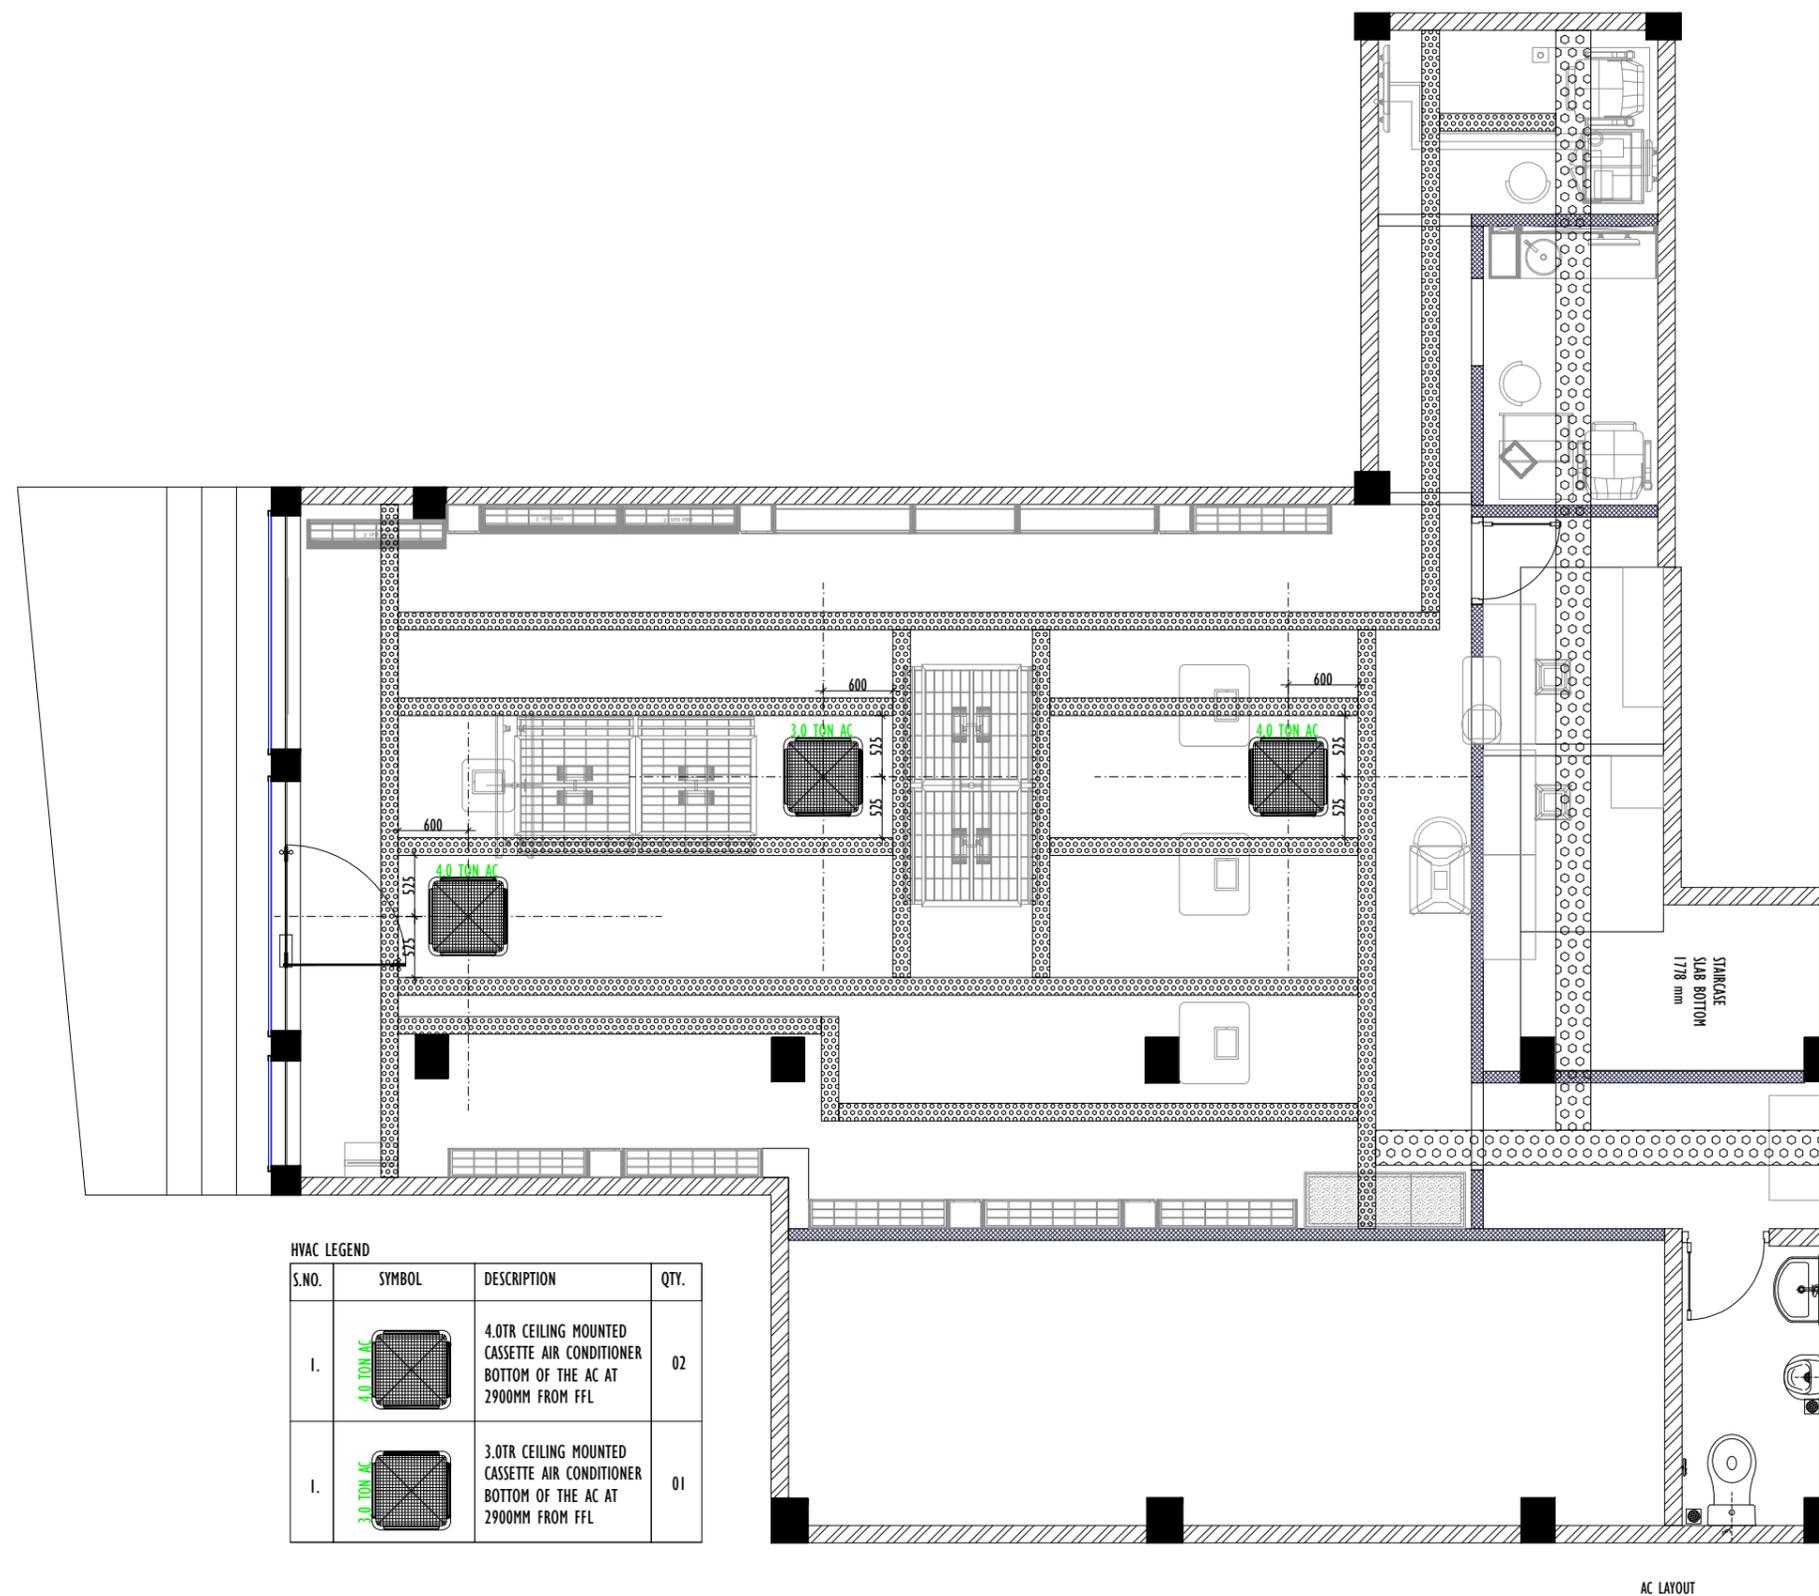

**HVAC LEGEND**

S.NO.	SYMBOL	DESCRIPTION	QTY.
I.		4.0TR CEILING MOUNTED CASSETTE AIR CONDITIONER BOTTOM OF THE AC AT 2900MM FROM FFL	02
I.		3.0TR CEILING MOUNTED CASSETTE AIR CONDITIONER BOTTOM OF THE AC AT 2900MM FROM FFL	01

**GENERAL NOTES :-**

- DO NOT SCALE FROM THE DRAWINGS.
- DIMENSIONS TO BE READ AND NOT MEASURED.
- ALL DIMENSIONS ARE IN MM, UNLESS NOTED OTHERWISE.
- ALL DRAWINGS SHOULD BE READ IN CONJUNCTION WITH OTHER RELEVANT ELECTRICAL, REFLECTED CEILING PLAN AND ALL RELEVANT SECTIONS.
- ANY DISCREPANCIES ARE TO BE BROUGHT TO THE ATTENTION OF THE ARCHITECT AND RESOLVED BEFORE COMMENCEMENT OF ANY WORK.
- THIS DRAWING IS THE COPYRIGHT OF LENSKART.COM & MUST NOT BE REPLICATED.

**DISCLAIMER :-**

"THIS DRAWING OR IDEA OR CONCEPT OR ARTWORK, INCLUDING THE ATTACHMENTS OR SAMPLES OR SUPPORTINGS THEREOF (SAID THE "CONCEPT"), IS SOLELY DEVELOPED BY LENSKART.COM, IS INTENDED FOR THE PURPOSE OF BUSINESS DEVELOPMENT, TO ONE OR MORE SPECIFIC INDIVIDUALS AND/OR ENTITIES AND HEREBY CLASSIFIED AS THE "INTELLECTUAL PROPERTY" OF LENSKART.COM, WHICH IS PRIVILEGED AND CANNOT BE USED, AS WHOLE OR IN PARTS OR IN ANY ALTERED FORM, WITHOUT A WRITTEN PERMISSION FROM THE MANAGEMENT OF LENSKART.COM. ANY SUCH UNAUTHORIZED USAGE SHALL BE CONSIDERED AS ILLEGITIMATE AND UNLAWFUL."

**SITE DETAILS**

STORE AREA (SQ.FT.)	1159 SQ.FT
EXISTING SLAB MAXIMUM BOTTOM HEIGHT FROM F.F.L	3900mm
EXISTING BEAM MINIMUM BOTTOM HEIGHT FROM F.F.L	3600mm
BOTTOM OF CABLE TRAY HEIGHT FROM F.F.L.	2900MM
FALSE CEILING BOTTOM HT.	NO FALSE CEILING
WALL FIXTURE HEIGHT	2400MM
BULKHEAD BOTTOM	2800 MM

**NOTE:**

**STATUS**

**GOOD FOR CONSTRUCTION**

R.No.	DATE	REVISION DESCRIPTION	DR.	CK.	AP.

**PROJECT TITLE:**  
2025- Lenskart Store

**SITE LOCATION:**  
BILASIPARA-COCO

**DRAWING TITLE:**  
RCP LAYOUT

<b>DRAWING NO:</b> ASM-BPR-CC- 13	<b>REVISION:</b> R0
<b>DATE:</b> 22.11.2025	<b>SCALE:</b> 1:60
<b>DRAWN BY:</b> Ar. Praveen Singh	<b>CHECKED BY:</b> 
	<b>APPROVED BY:</b> 

**CABLE TREY LEGEND**

S.NO	SYMBOL	DESCRIPTION	LENGTH
1.		300MM WIDE CABLE TREY AT 2900MM FROM FFL	13 RMT.
2.		150MM WIDE CABLE TREY AT 2900MM FROM FFL	63 RMT.

**LIGHTING LEGEND**

S.N	SYMBOL	DESCRIPTION	QTY.	WATT.	TOTAL WATT.
01		TRACK LIGHT 3000K WHITE COLOUR	40	25	1000
02		PANEL LIGHT 4000K - WHITE COLOR	04	18	72
03		PANEL LIGHT 3000K - WHITE COLOR	28	18	504
04		RECESSED SPOT LIGHT 3000K - BLACK COLOR	05	18	90
06		TRACK LENGTH - WHITE COLOR	10 X 2 METERS	01 X 1 METERS	

TOTAL -1666W

**CCTV LEGEND**


S.NO.	SYMBOL	DESCRIPTION	QTY.
1.		CCTV CAMERA SPECIFICATION & INSTALLATION AS PER VENDOR - PROVIDE CAT 6 CABLE IN CEILING FOR CAMERA WITH CONNECTION TO CASH COUNTER FOR CONTROL BOX	10
2.		CCTV CONTROL BOX / DVR	01

**SPEAKER LEGEND**

S.NO	SYMBOL	DESCRIPTION	QTY.
1.		WALL MOUNTED SPEAKER @ HT 2550MM FROM FFL	04
2.		CONTROL BOX FOR MUSIC SYSTEM IN PICKUP COUNTER @ LVL +450MM FROM FFL	01

**HVAC LEGEND**

S.NO.	SYMBOL	DESCRIPTION	QTY.
1.		4.0TR CEILING MOUNTED CASSETTE AIR CONDITIONER BOTTOM OF THE AC AT 2900MM FROM FFL	02
1.		3.0TR CEILING MOUNTED CASSETTE AIR CONDITIONER BOTTOM OF THE AC AT 2900MM FROM FFL	01

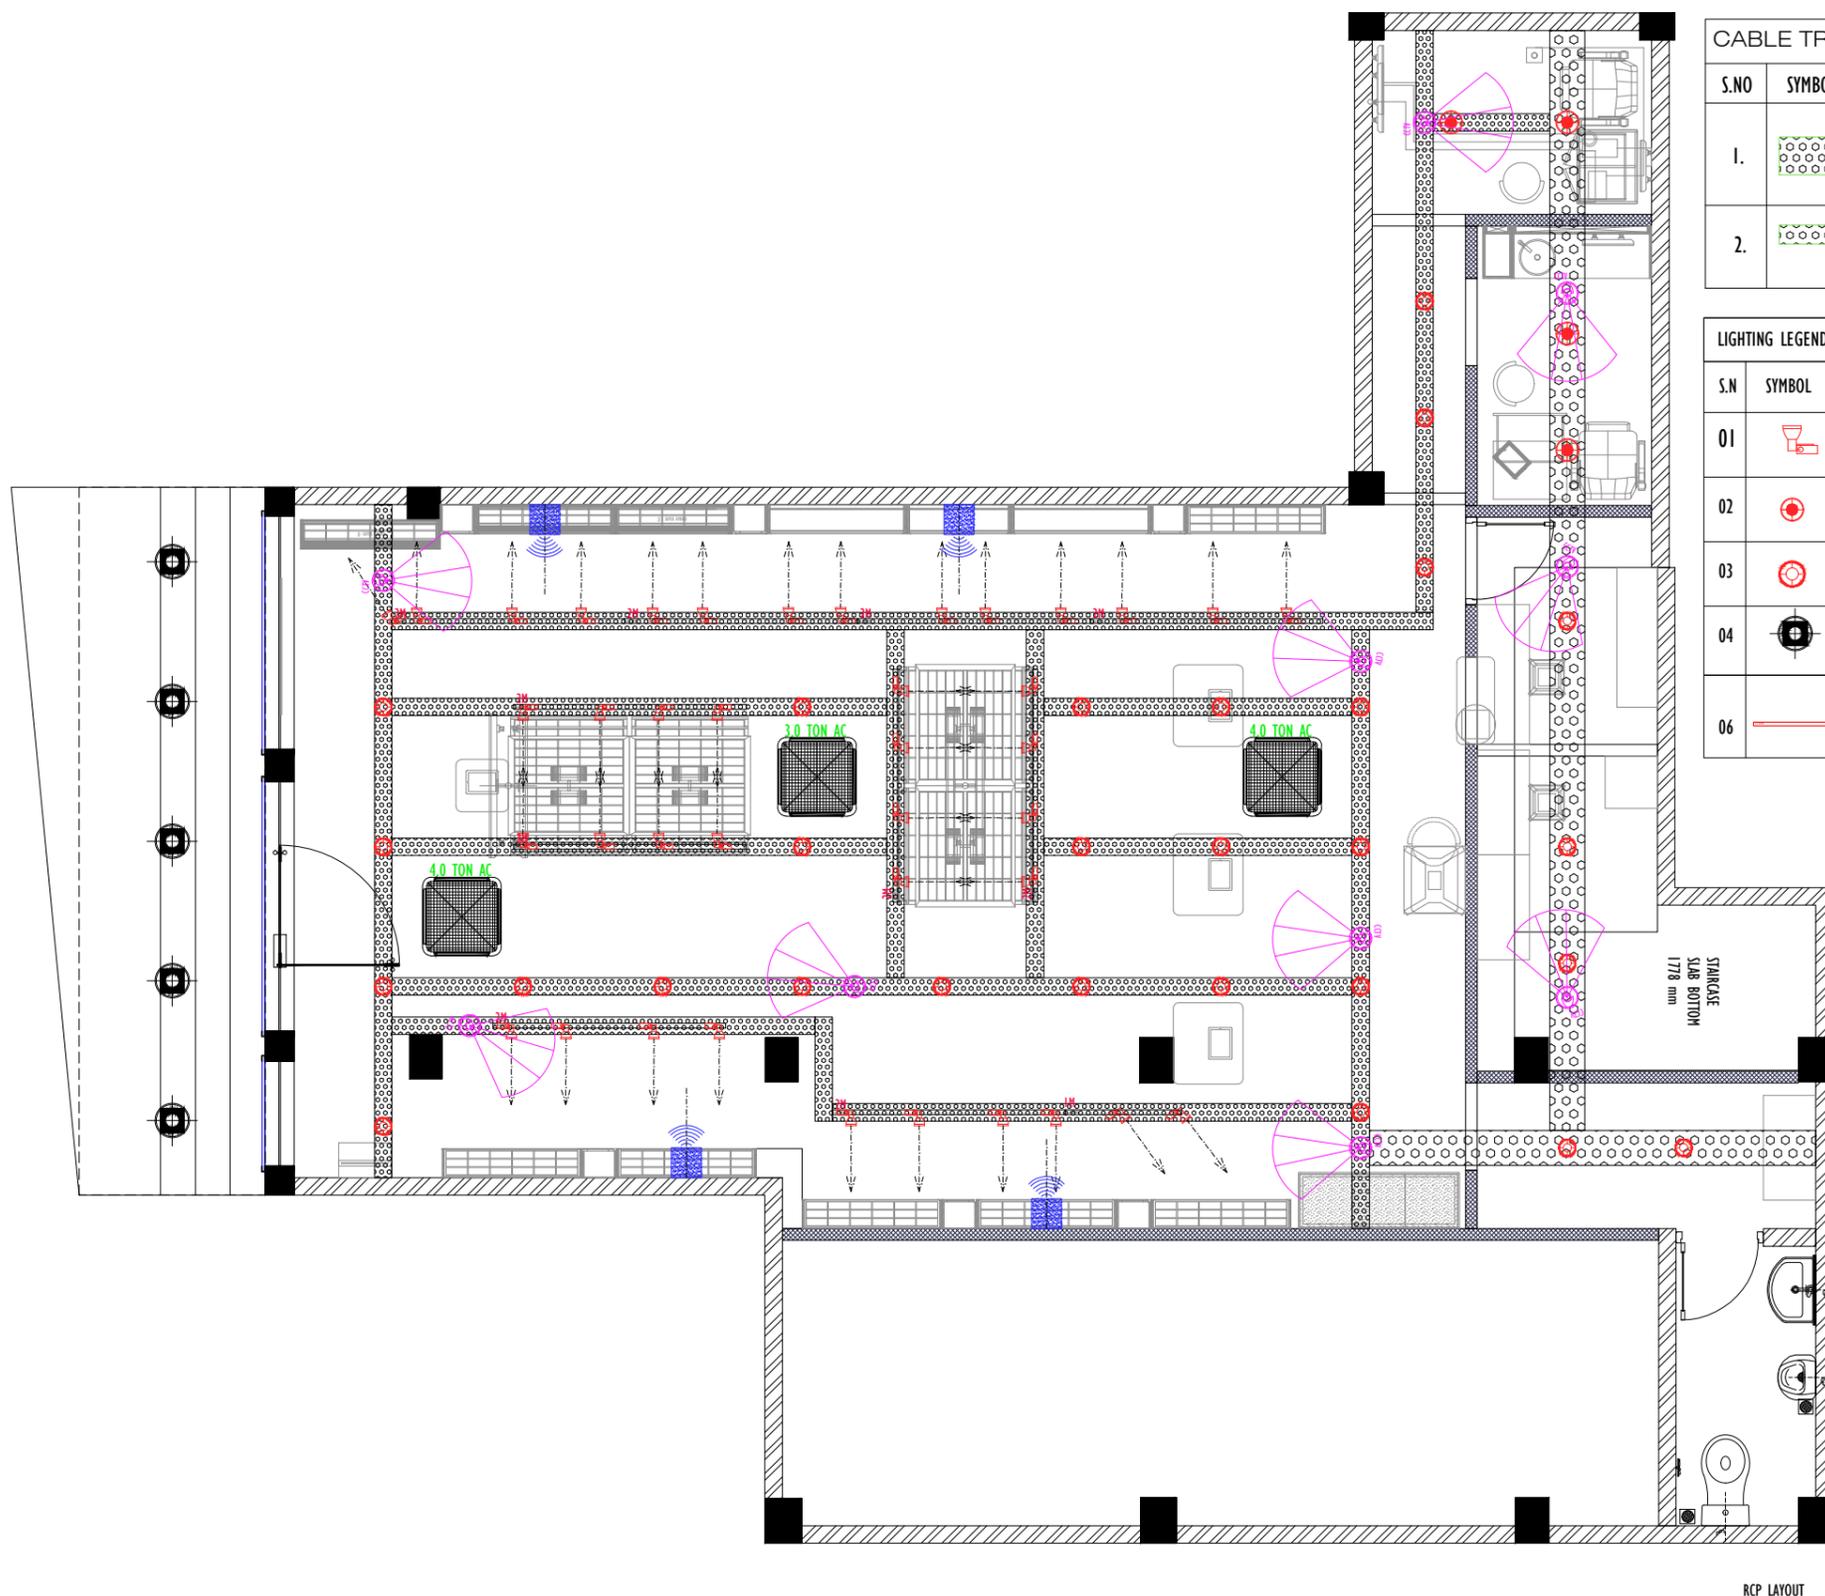

RCP LAYOUT

