

PROJECT TITLE:

FEDERAL BANK CHEMBUR

DRAWING TITLE:

RCP LAYOUT

STATUS:

GOOD FOR CONSTRUCTION

R0

AS SHOWN@A3

NAEEM

PROJECT NO.:

DRAWING NO. :

REVISION:

DRAWN BY:

CHECKED BY:

REV. DATE DESCRIPTION

1. CONTRACTOR MUST VERIFY & CHECK ALL DIMENSIONS, DRAWINGS, DETAILS & SPECIFICATIONS BEFORE PROCEEDING WITH THE WORK.

2. ALL DIMENSIONS / LEVELS ARE BASED ON THE SURVEY DRAWINGS, CONTRACTOR MUST VERIFY ALL DIMENSIONS ON SITE BEFORE PROCEEDING WITH THE

3. ALL DIAGRAMMATIC REPRESENTATIONS OF FIXTURES IN DRAWINGS BY ASPECT ARE FOR REPRESENTATIONAL PURPOSE ONLY, AND ARE NOT SPECIFIC TO INDIVIDUAL

4. ALL SERVICES INCORPORATED IN THE DRAWINGS ARE WITH REFERENCE TO DRAWINGS RECEIVED FROM


THIS DOCUMENT IS AN INTELLECTUAL PROPERTY OF REPRODUCED. RETAINED OR DISCLOSED TO ANY UNAUTHORIZED PERSON. PRODUCTION DRAWINGS TO BE COMPLETED BY MANUFACTURER OR CONTRACTOR AND TO BE CHECKED BY ASPECT PRIOR TO CONSTRUCTION STRUCTURAL ENGINEER MUST BE EMPLOYED WHERE APPLICABLE.

TO CHECKING AND APPROVAL.

DO NOT SCALE OFF DRAWING. FIGURED DIMENSIONS TO BE TAKEN IN PREFERENCE TO THOSE SCALED. DIMENSIONS TO BE VERIFIED ON SITE. ANY DISCREPANCIES TO BE REPORTED TO ASPECT IMMEDIATELY.



HVAC LEG	GEND:		
SL NO.	DESCRIPTION		QTY
1.	DX CASSETTE	تراسي	05
2.	SUPPLY AIR DUCT - RECTANGULAR	7	-
3.	FRESH AIR DUCT-OVAL	7	-
4.	RETURN AIR GRILL		00
5.	SUPPLY AIR GRILL	<u></u>	00
6.	VRF - OUT DOOR UNIT	10 MF 000 627 M60 Select	02
7.	VCD	N	00
8.	SECTION MARKER	1	01
9.	DX HIWALL	0 0	03
10.	VRF COPPER PIPE & REFNETS		-
11.	DRAIN PIPE		-
12.	ACOUSTIC INSULATION		-
13.	THERMAL INSULATION		-
14.	SUPPLY FIRE DAMPER	 8	00
15.	VRF DUCTABLE UNIT	F802	00
15.	WALL TOILET EXHAUST FAN		01
15.	MS PLATFORM FOR ODU		02
16.	CABINET INLINE FRESH AIR FAN		00
17.	AC CABLE TRAY	(acces	-

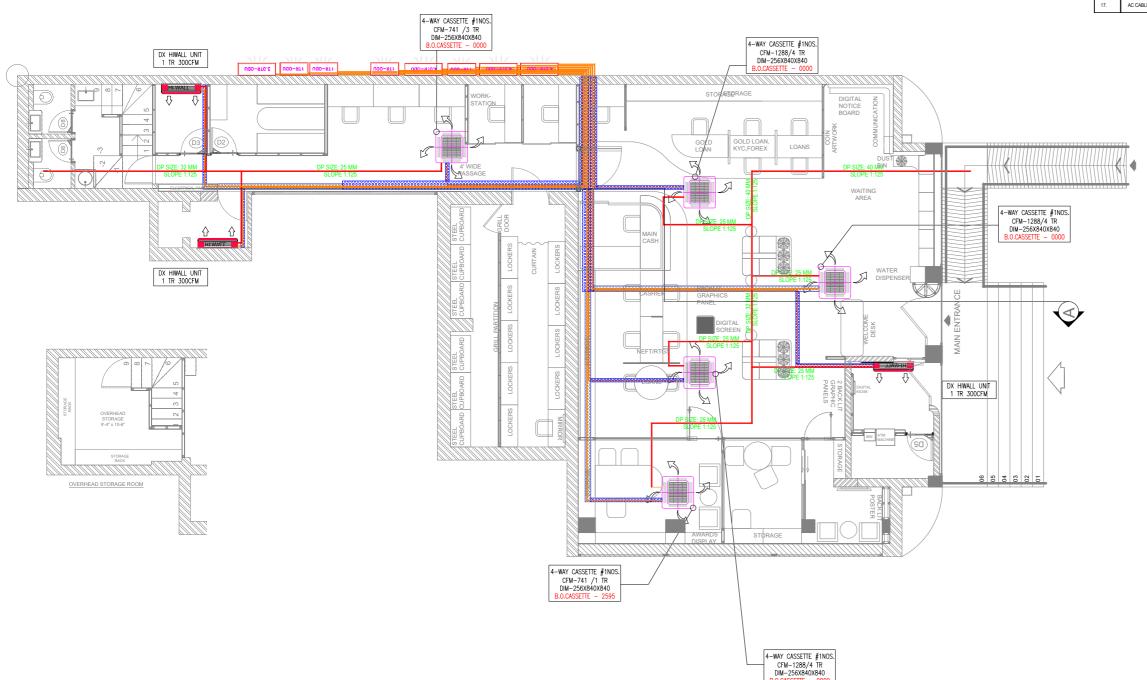

PROJECT TITLE:
FEDERAL BANK
CHEMBUR

DRAWING TITLE:

HVAC LAYOUT

STATUS:

GOOD FOR CONSTRUCTION

PROJECT NO.:

DRAWING NO.:

REVISION: RO

DATE:

SCALE: AS SHOWN@A3

DRAWN BY: NAEEM

CHECKED BY: RJ

REV. DATE DESCRIPTION

NOTES:

CONTRACTOR MUST VERIFY & CHECK ALL
DIMENSIONS, DRAWINGS, DETAILS & SPECIFICATIONS
ON SITE AND REPORT ANY DISCREPANCIES TO ASPECT
BEFORE PROCEEDING WITH THE WORK.
 ALL DIMENSIONS / LEVELS ARE BASED ON THE
SURVEY DRAWINGS. CONTRACTOR MUST VERIFY ALL
DIMENSIONS ON SITE BEFORE PROCEEDING WITH THE

3. ALL DIAGRAMMATIC REPRESENTATIONS OF FIXTURES IN DRAWINGS BY ASPECT ARE FOR REPRESENTATIONAL PURPOSE ONLY, AND ARE NOT SPECIFIC TO INDIVIDUAL

4. ALL SERVICES INCORPORATED IN THE DRAWINGS ARE WITH REFERENCE TO DRAWINGS RECEIVED FROM THE MEP CONSULTANT.

THIS DOCUMENT IS AN INTELLECTUAL PROPERTY OF ASPECT. THIS DRAWING CANNOT BE COPIED, REPRODUCED, RETAINED OR DISCLOSED TO ANY UNAUTHORIZED PERSON. PRODUCTION DRAWINGS TO BE COMPLETED BY MANUFACTURER OR CONTRACTOR AND TO BE CHECKED BY ASPECT PRIOR TO CONSTRUCTION STRUCTURAL ENGINEER MUST BE EMPLOYED WHERE APPLICABLE.

ALL DIMENSIONS AND FINAL FINISHES TO B
TO CHECKING AND APPROVAL.

DO NOT SCALE OFF DRAWING. FIGURED DIMENSIONS TO BE TAKEN IN PREFERENCE TO THOSE SCALED. DIMENSIONS TO BE VERIFIED ON SITE. ANY DISCREPANCIES TO BE REPORTED TO ASPECT IMMEDIATELY.

