

* NOTE:
- OPEN CEILING CONCEPT



VATIKA TOWER,
FARIDABAD.

LENSKART.COM
7th FLOOR, TOWER A | VATIKA MINDSCAPES | 12/3 MATHURA ROAD | NH2,
SECTOR 27D | FARIDABAD-121013, NEAR SARAI METRO STATION
www.lenskart.com

- GENERAL NOTES :-**
- PLEASE TREAT THE MARKED DIMENSIONS IN THE DRAWING AS FINAL.
 - ALL DRAWINGS SHOULD BE READ IN CONJUNCTION WITH OTHER RELEVANT ELECTRICAL, REFLECTED CEILING PLAN AND ALL RELEVANT SECTIONS.
 - ANY DISCREPANCIES ARE TO BE BROUGHT TO THE ATTENTION OF THE ARCHITECT AND RESOLVED BEFORE COMMENCEMENT OF ANY WORK.
 - THIS DRAWING IS THE COPYRIGHT OF LENSART.COM & MUST NOT BE REPLICATED.

DISCLAIMER :-


"THIS DRAWING OR IDEA OR CONCEPT OR ARTWORK, INCLUDING THE ATTACHMENTS OR SAMPLES OR SUPPORTINGS THEREOF (SAID THE "CONCEPT"), IS SOLELY DEVELOPED BY LENSART.COM, IS INTENDED FOR THE PURPOSE OF BUSINESS DEVELOPMENT, TO ONE OR MORE SPECIFIC INDIVIDUALS AND/OR ENTITIES AND HEREBY CLASSIFIED AS THE "INTELLECTUAL PROPERTY" OF LENSART.COM, WHICH IS PRIVILEGED AND CANNOT BE USED, AS WHOLE OR IN COLTS OR IN ANY ALTERED FORM, WITHOUT A WRITTEN PERMISSION FROM THE MANAGEMENT OF LENSART.COM. ANY SUCH UNAUTHORIZED USAGE SHALL BE CONSIDERED AS ILLEGITIMATE AND UNLAWFUL."

SITE DETAILS	
TOTAL STORE AREA	1075.00 SQ.FT
DEVELOPED AREA (SQFT)	1075.00 SQ.FT
STORE/ PICKUP & TOILET AREA (SQFT)	111.00 & 33.00 SQ.FT
PROPOSED CLINIC AREA (sqft)	122.00 SQ.FT
PROPOSED RETAIL AREA (sqft)	809.00 SQ.FT
EXISTING SLAB HEIGHT FROM F.F.L. (MM)	2890 MM
EXISTING BEAM BOTTOM HT. FROM F.F.L. (MM)	2590 MM
EXISTING FACADE HEIGHT FROM F.F.L. (MM)	2170MM
PROPOSED FIXTURE HEIGHT FROM F.F.L. (MM)	2400 MM
PROPOSED FACADE HEIGHT FROM F.F.L. (MM)	2170 MM
AC TYPE:- CASSETTE AC	4.0 TON X 2 NOS. & 2.0 TON

LIGHTING LEGEND:						
Sr. nos.	SYMBOL	DESCRIPTION	QTY.	WATT	TOTAL WATT	
1.		25w- Track light 3000k	30	25	750	
2.		18w- Surface mounted 4000k	04	18	72	
3.		18w- Surface mounted 3000k	18	18	324	
4.		20w- Concealed light 3000k	03	20	60	
5.		Single ckt track 1 mtr	04	00	00	
6.		Single ckt track 2 mtr	06	00	00	
7.		1x18w T5. 2/ 4Feet.	01	28	28	
8.		Water Sprinkler	00	-	-	
9.		Smoke Detector	00	-	-	
10.		MCP	00	-	-	
11.		Hooter	00	-	-	
12.		Wall mounted speaker	04	-	-	
13.		Dome Camera	08	-	-	

R.No.	DATE	REVISION DESCRIPTION	DR.	CK.	AP.

PROJECT TITLE: NESA_TURA, GUWAHATI (COCO)	
COORDINATED RCP PLAN	SHEET NO: 04
DRAWING NO: VIS-LK-COCO_4.0	SHEET SIZE: A3
DATE: 29-11-2025	SCALE: NTS
DRAWN BY:	REVISION: R0
CHECKED BY:	APPROVED BY:

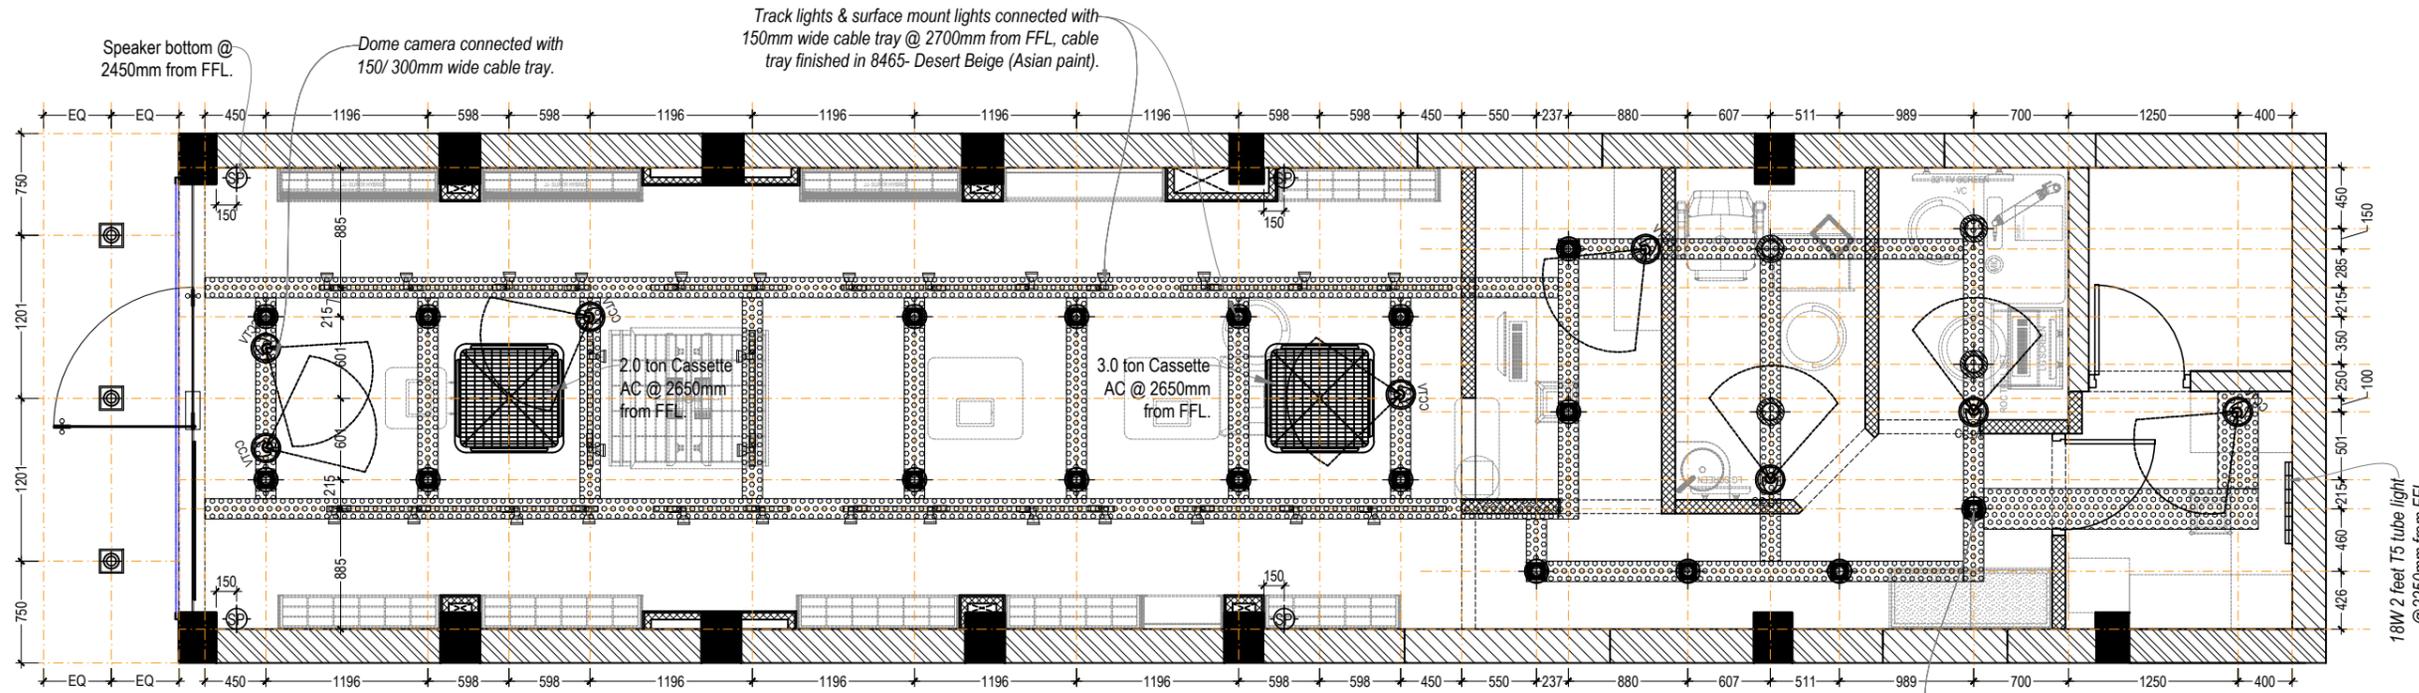

NOTES - AC

- # Total 5.0 ton AC capacity is required.
- # The AC's are 2.0 ton & 3.0 ton each or specified
- # The standard size of Cassette AC has been taken as 800 x 800mm
- # This can vary from brand to brand. The center of AC has to match the drawing.

